





PERSPECTIVE VIEW

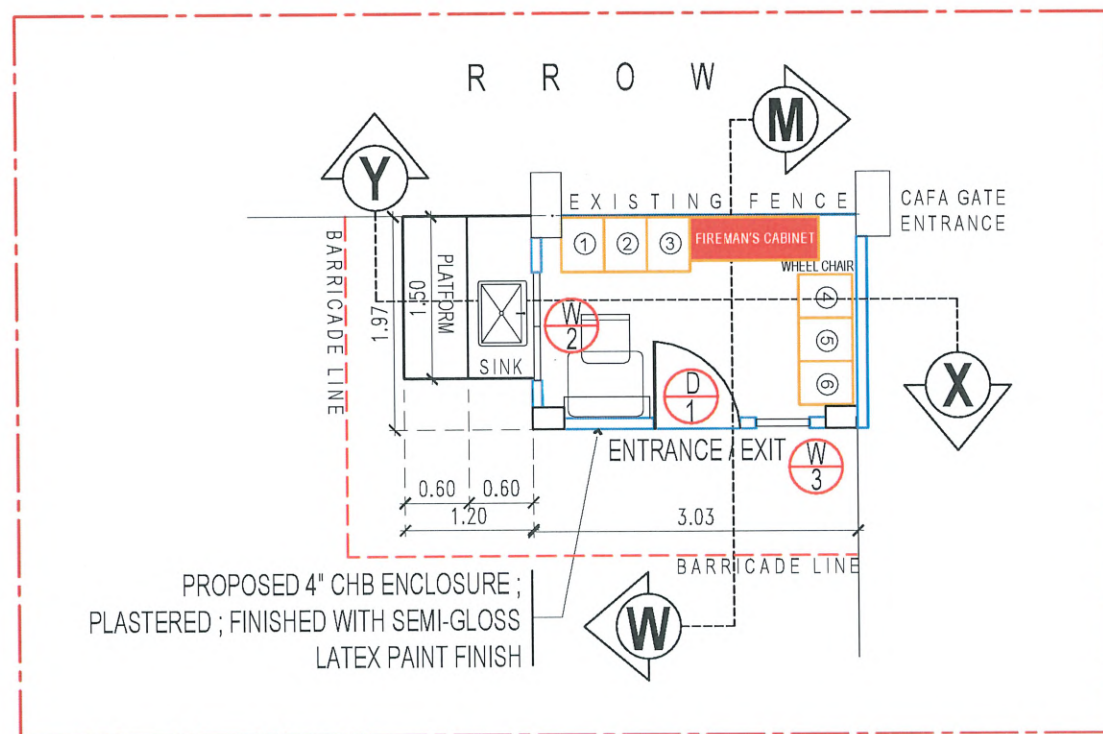

PROPOSED CAFA LOCKER ROOM

SCALE 1:70M

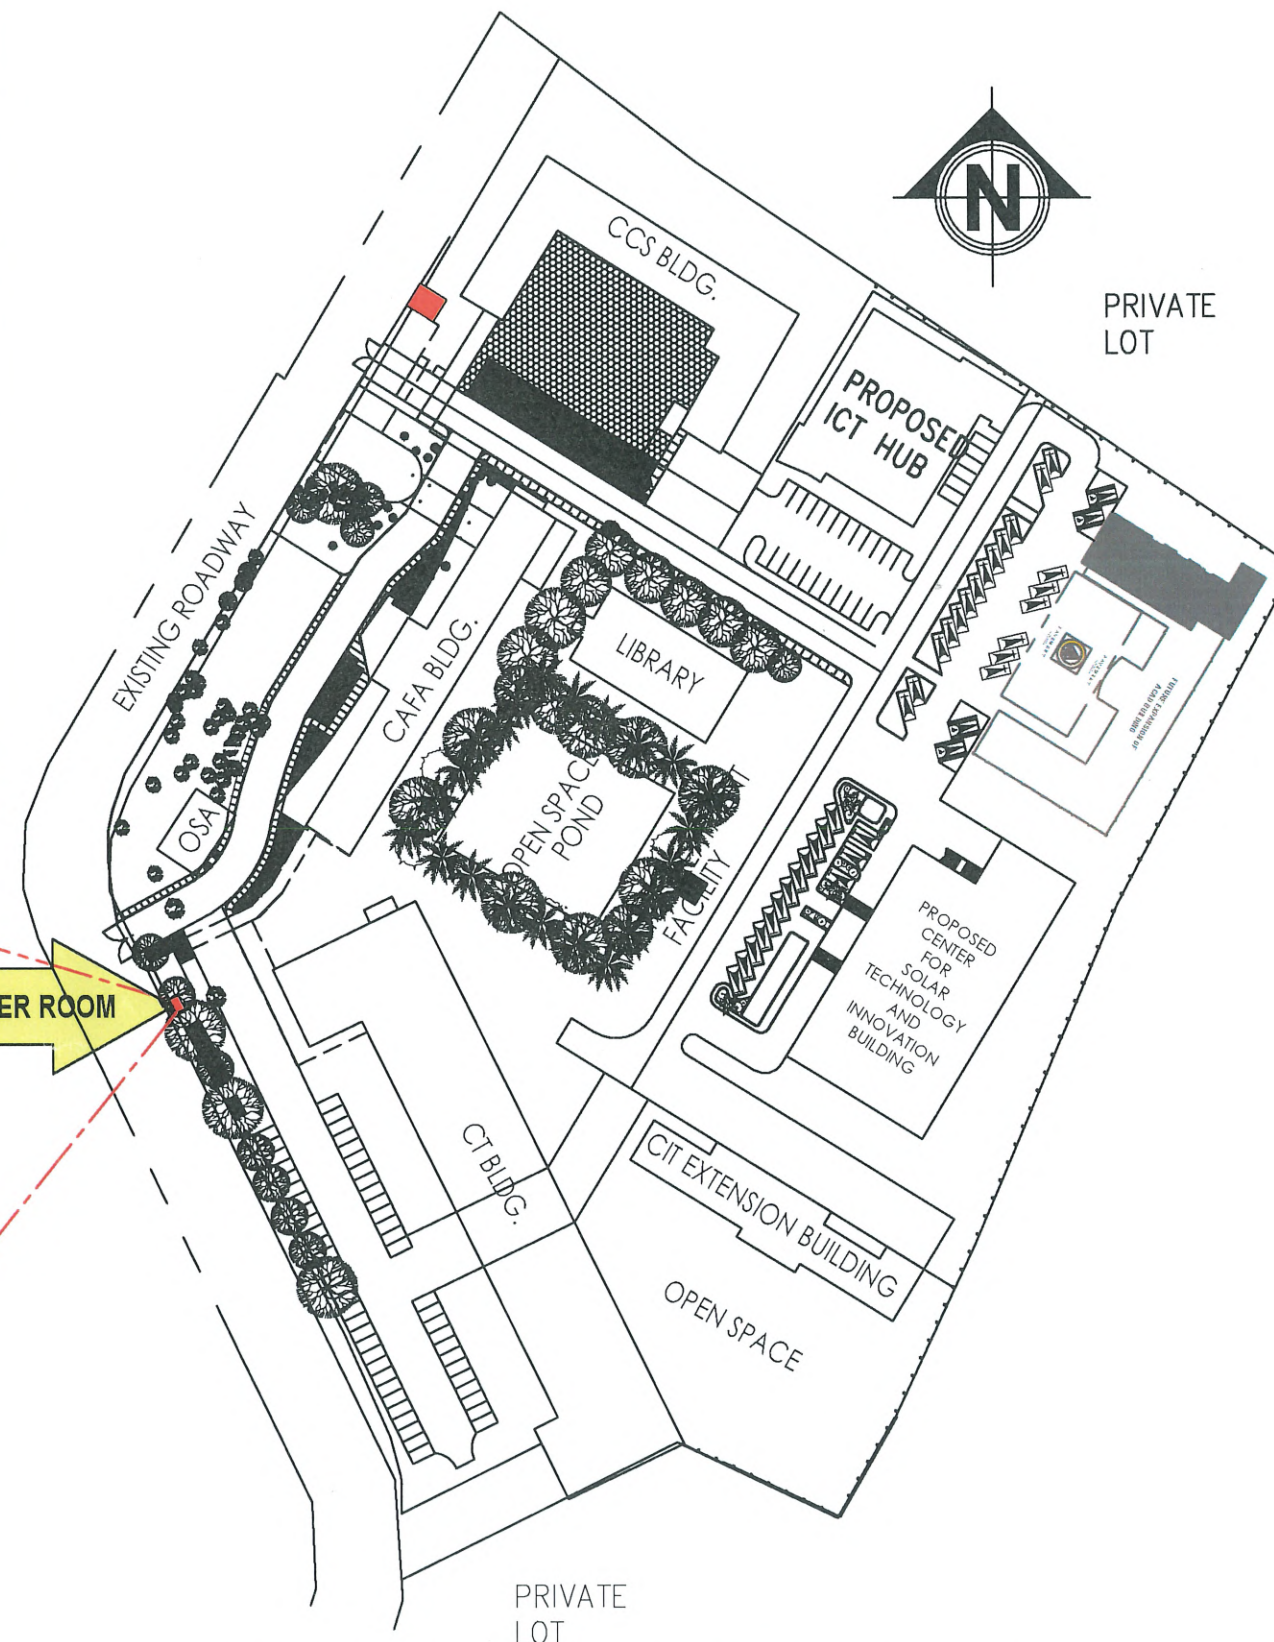

SAN ISIDRO CAMPUS SITE DEVELOPMENT PLAN

SCALE : NTS



TARLAC STATE UNIVERSITY
Facilities Development and
Management Office
Romulo Boulevard, Tarlac City, Philippines 2300

PROJECT TITLE:
CONSTRUCTION OF SECURITY GUARD LOCKER ROOM
PROJECT LOCATION:
SAN ISIDRO & LUCINDA CAMPUS,
TARLAC STATE UNIVERSITY

PREPARED BY:

MR. WENCIE S. MANIBOG
DRAFTSMAN, OFDM-PDU

CHECKED BY:

AR. CHERRY L. FABIANES
HEAD, OFDM-PDU

CERTIFIED BY:

AR. ARLEN M. GUIEB
DIRECTOR, OFDM

REQUESTING OFFICE:

DR. JAYSON R. FELIX
CIVIL SECURITY OFFICER

RECOMMENDING APPROVAL:


ATTY. WILMARK J. RAMOS, DBA
VP FOR ADMINISTRATION

APPROVED:

DR. ARNOLD E. VELASCO
PRESIDENT


SHEET CONTENTS:
AS SHOWN
DATE: FEBRUARY 2025

SHEET NO:
A - 01
PAGE NO:
01/16

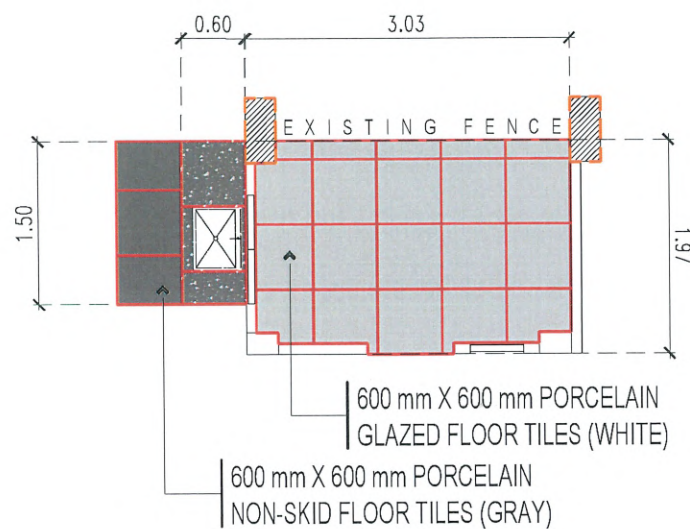


FLOOR TILE PATTERN

SCALE 1:70M

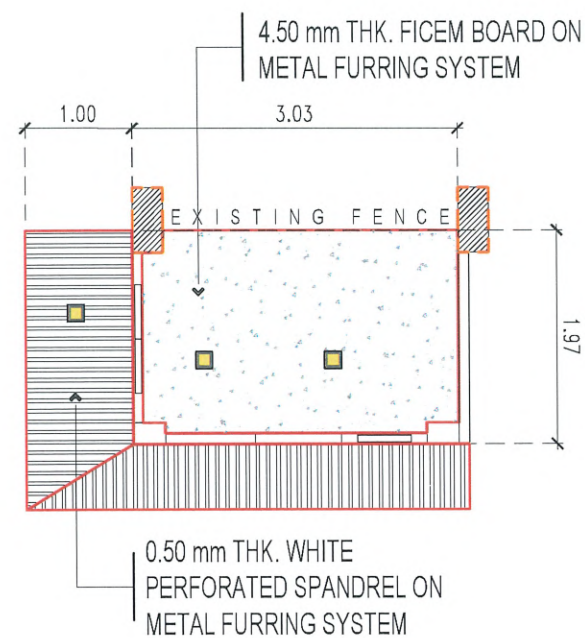

CEILING PLAN

SCALE 1:70M

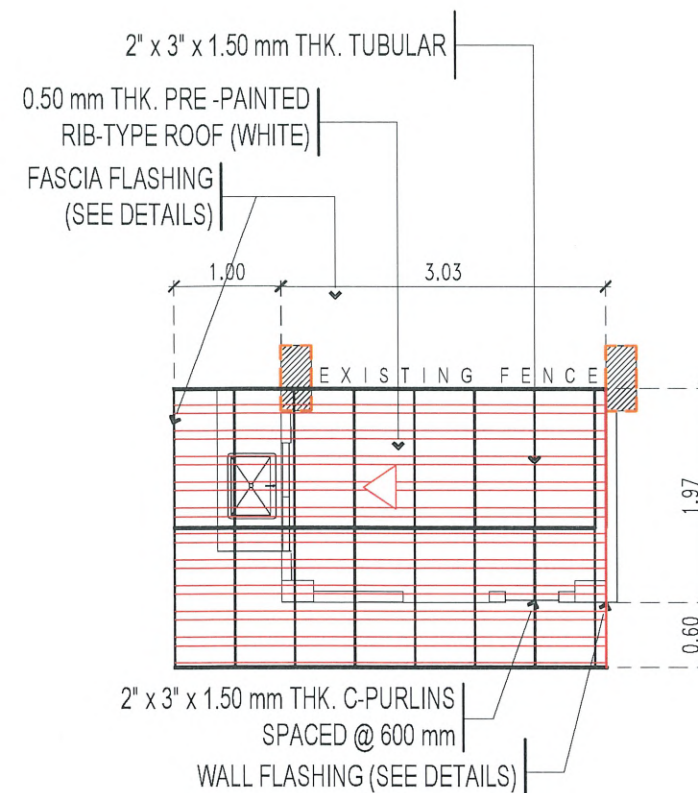


ROOF PLAN

SCALE 1:70M


NOTE :

1. SURFACE PREPARATION; SCRAPING OF OLD PAINT & APPLICATION OF BODY-FILLER IN ALL UNEVEN SURFACES.
2. REPAINTING OF EXTERIOR AND INTERIOR WALLS OF LOCKER ROOM.
3. APPLY 1 COAT OF PRIMER & 2 COATS OF SEMI GLOSS LATEX PAINT (TULLE WHITE)
4. ALL PROPOSED WALL MUST HAVE WALL FOOTING.
5. PROVIDE TEMPORARY BARRICADE/ COVER WITHIN THE CONSTRUCTION AREA/ROOM USING PLYWOOD/G.I. SHEET WITH STABLE FRAME AND INCLUDE SAFETY SIGNAGES. DO NOT USE "BLUE SACK" AS COVER.

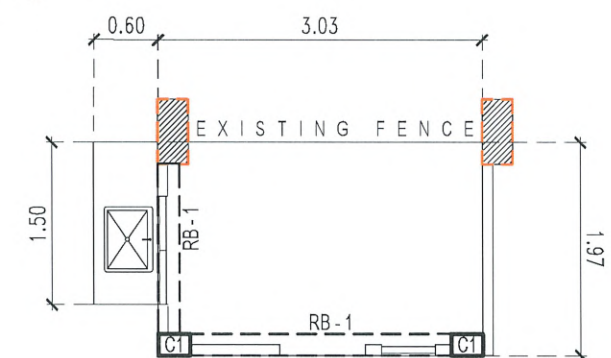

ROOF BEAM PLAN

SCALE 1:70M

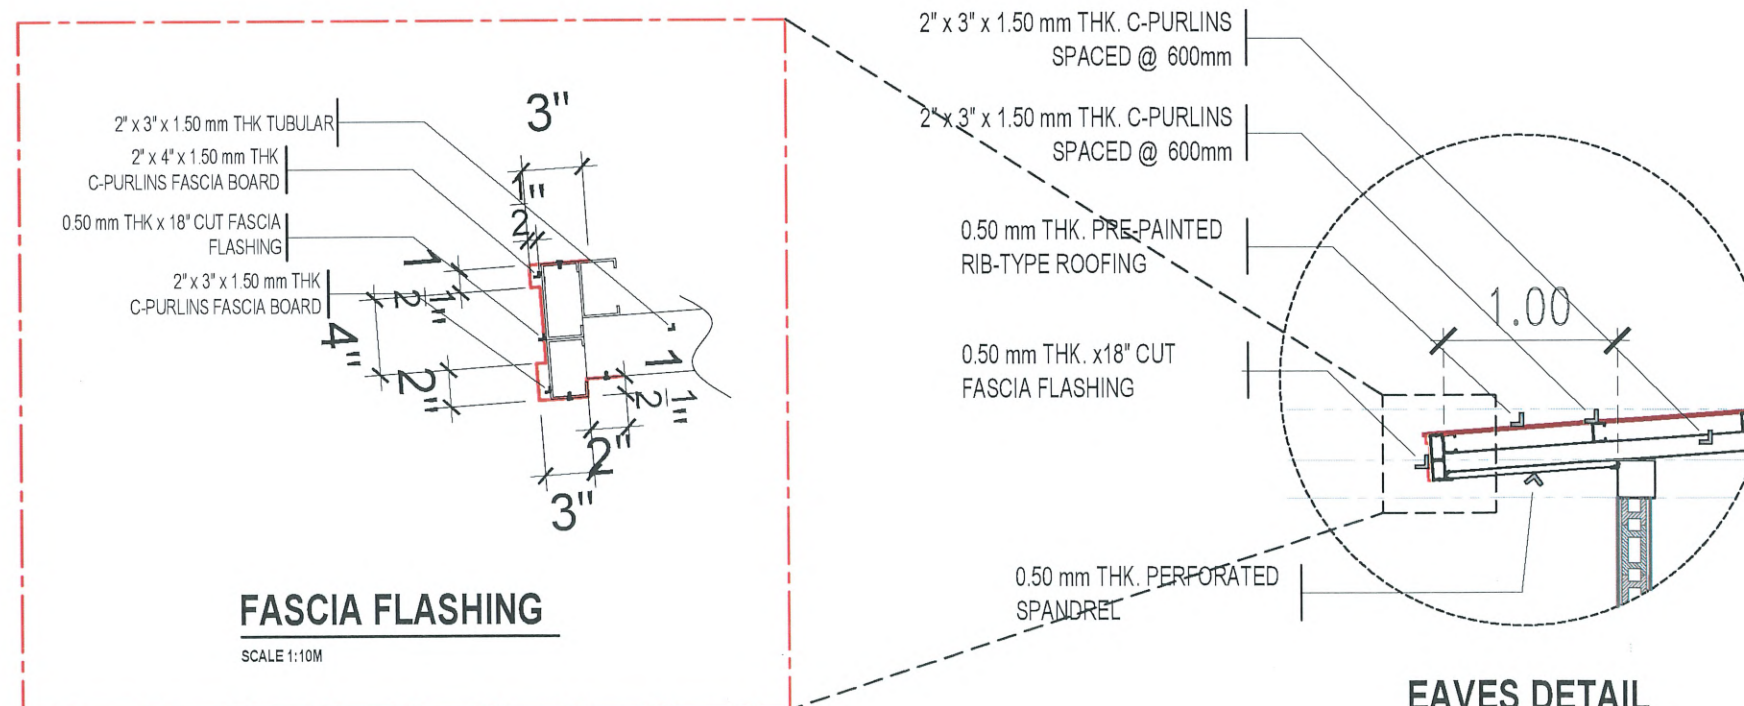


FASCIA FLASHING

SCALE 1:10M

EAVES DETAIL

SCALE 1:30M

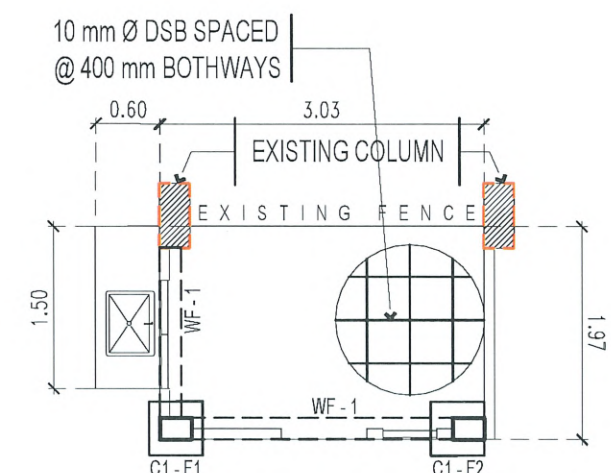

FOUNDATION PLAN

SCALE 1:70M





TARLAC STATE UNIVERSITY
Facilities Development and
Management Office
Romulo Boulevard, Tarlac City, Philippines 2300

PROJECT TITLE:	CONSTRUCTION OF SECURITY GUARD LOCKER ROOM	PREPARED BY:	MR. WENCIE S. MANIBOG DRAFTSMAN, OFDM-PDU	CHECKED BY:	AR. CHERRY L. FABIANES HEAD, OFDM-PDU	CERTIFIED BY:	AR. ARLEN M. GUIEB DIRECTOR, OFDM	REQUESTING OFFICE:	DR. JAYSON R. FELIX CIVIL SECURITY OFFICER	RECOMMENDING APPROVAL:	ATTY. WILMARK J. RAMOS, DBA VP FOR ADMINISTRATION	APPROVED:	DR. ARNOLD E. VELASCO PRESIDENT	SHEET CONTENTS:	AS SHOWN	SHEET NO.:	A - 02
PROJECT LOCATION:	SAN ISIDRO & LUCINDA CAMPUS, TARLAC STATE UNIVERSITY													DATE: FEBRUARY 2025		PAGE NO.:	02/16


NOTE :

1. SURFACE PREPARATION; SCRAPING OF OLD PAINT & APPLICATION OF BODY-FILLER IN ALL UNEVEN SURFACES.
2. REPAINTING OF EXTERIOR AND INTERIOR WALLS OF LOCKER ROOM.
3. APPLY 1 COAT OF PRIMER & 2 COATS OF SEMI GLOSS LATEX PAINT (TULLE WHITE)
4. ALL PROPOSED WALL MUST HAVE WALL FOOTING.
5. PROVIDE TEMPORARY BARRICADE/ COVER WITHIN THE CONSTRUCTION AREA/ROOM USING PLYWOOD/G.I. SHEET WITH STABLE FRAME AND INCLUDE SAFETY SIGNAGES. DO NOT USE "BLUE SACK" AS COVER.

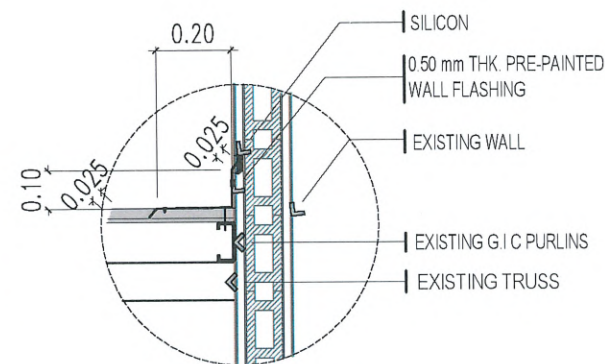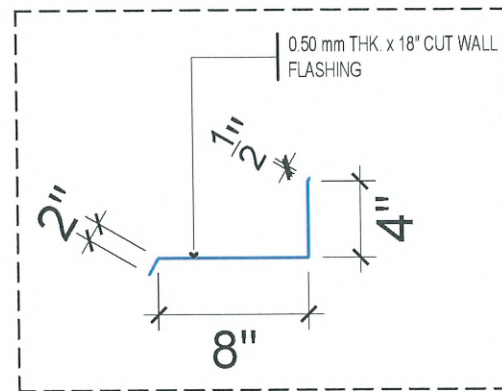


TYPICAL WALL FLASHING

SCALE 1:10M

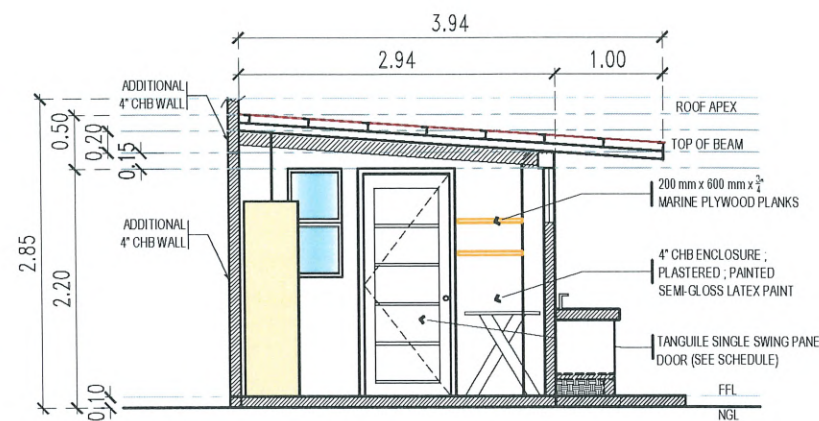


SECTION - X

SCALE 1:50M

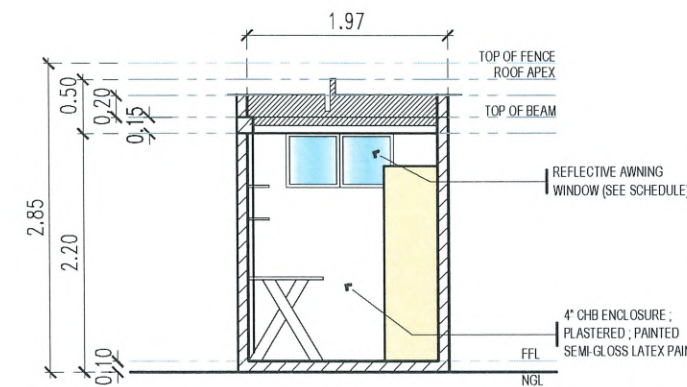


SECTION - W

SCALE 1:50M

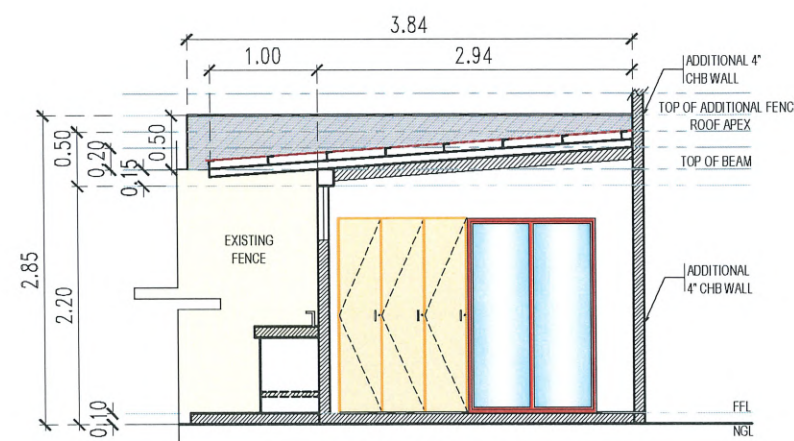


SECTION - Y

SCALE 1:50M

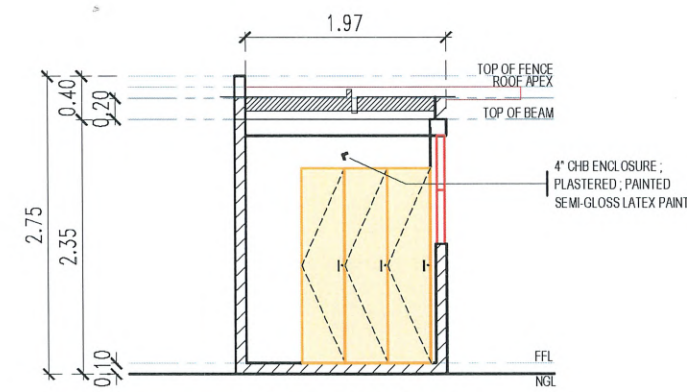


SECTION - M

SCALE 1:50M

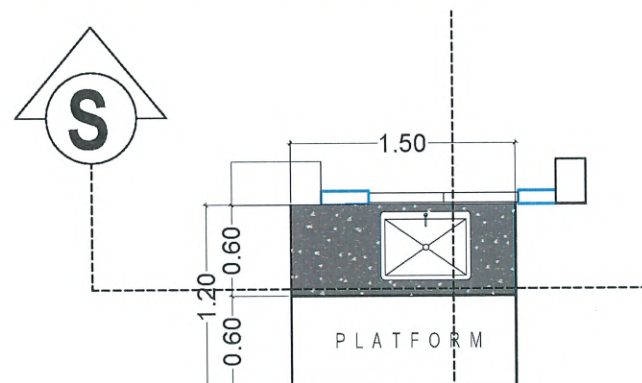


SINK FLOOR PLAN

SCALE 1:50M

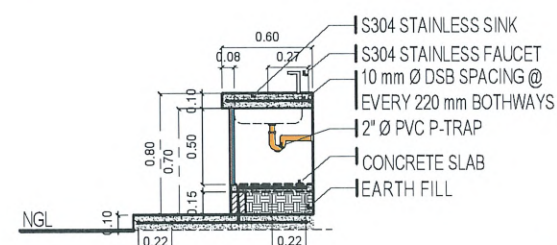



SECTION - R

SCALE 1:50M

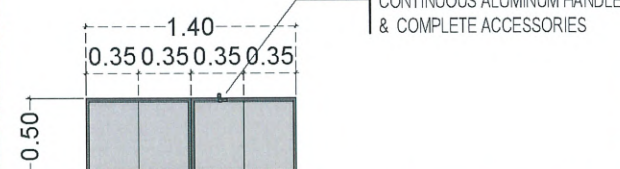

FRONT ELEVATION

SCALE 1:50M

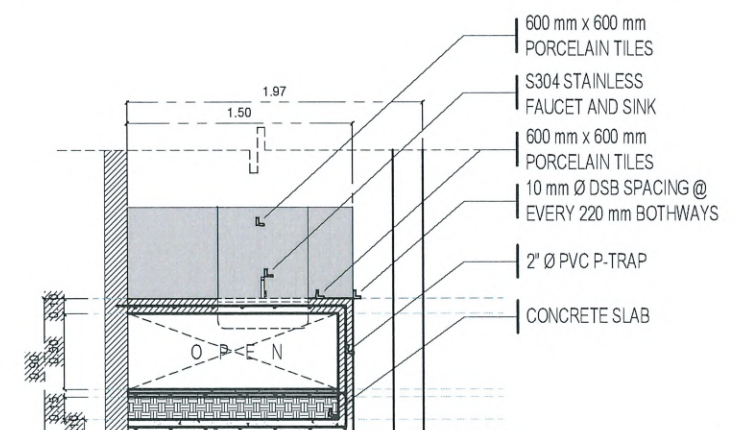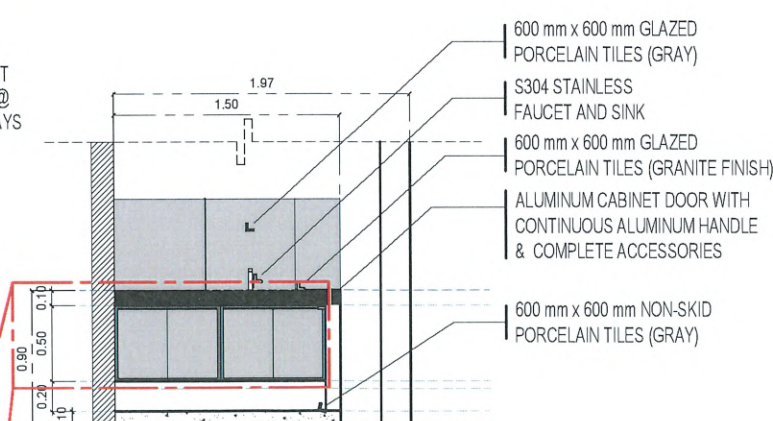

SECTION - S

SCALE 1:50M



TARLAC STATE UNIVERSITY
Facilities Development and
Management Office
Ramulo Boulevard, Tarlac City, Philippines 2300

PROJECT TITLE:
CONSTRUCTION OF SECURITY GUARD LOCKER ROOM
PROJECT LOCATION:
SAN ISIDRO & LUCINDA CAMPUS,
TARLAC STATE UNIVERSITY

PREPARED BY:

MR. WENGIE S. MANOBRO
DRAFTSMAN, OFDM-PDU

CHECKED BY:

AR. CHERRY L. FABIANES
HEAD, OFDM-PDU

CERTIFIED BY:

AR. ARLEN M. GUIEB
DIRECTOR, OFDM

REQUESTING OFFICE:

DR. JAYSON R. FELIX
CIVIL SECURITY OFFICER

RECOMMENDING APPROVAL:


ATTY. WILMARK J. RAMOS, DBA
VP FOR ADMINISTRATION

APPROVED:


DR. ARNOLD E. VELASCO
PRESIDENT

SHEET CONTENTS:
AS SHOWN
DATE: FEBRUARY 2025

SHEET NO:
A - 03
PAGE NO:
03/16


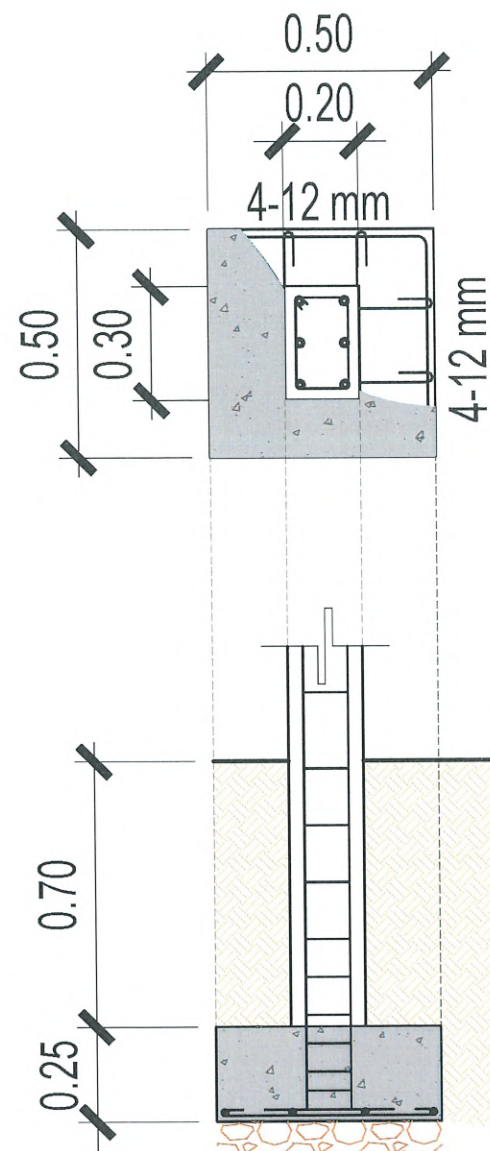


50 mm CONCRETE COVER
6 - 12 mm Ø VERTICAL BARS
USE : 10 mm Ø HORIZONTAL BARS
SPACING @ 2 - 50 mm , 2 - 75 mm , 2 - 100 mm, 2-150 mm REST - 200 mm

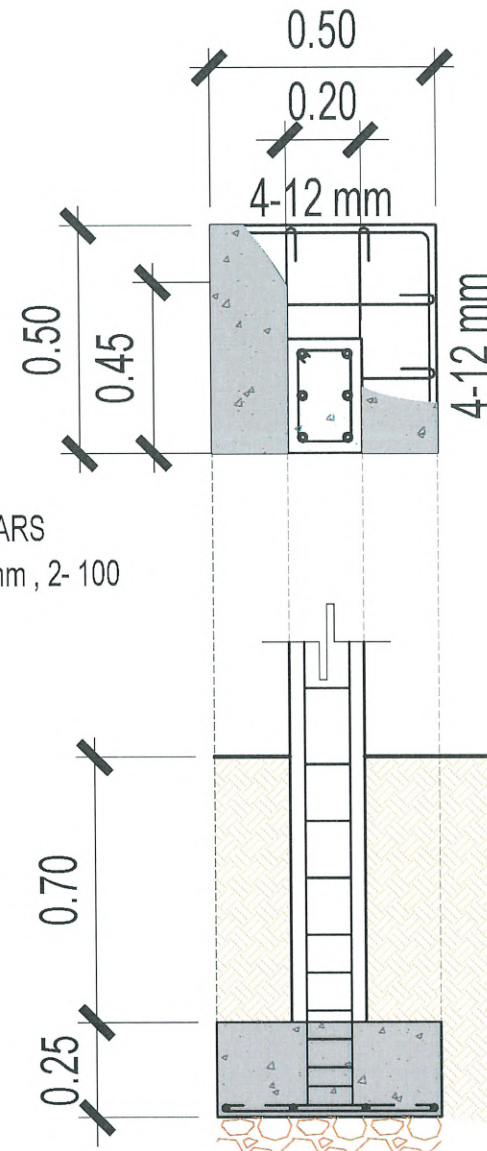

50 mm CONCRETE COVER
6 - 12 mm Ø VERTICAL BARS
USE : 10 mm Ø HORIZONTAL BARS
SPACING @ 2 - 50 mm , 2 - 75 mm , 2 - 100 mm, 2-150 mm REST - 200 mm

0.15
0.15
50 mm CONCRETE COVER
4 - 12 mm Ø CONTINUOUS BARS
USE : 10 mm Ø TIES SPACING @ 3 - 50 mm , 3 - 100 mm, 3-150 mm REST - 200 mm

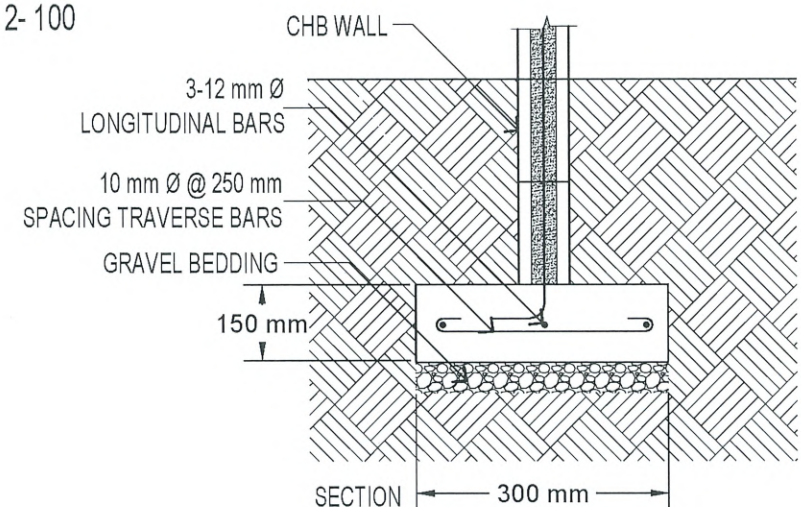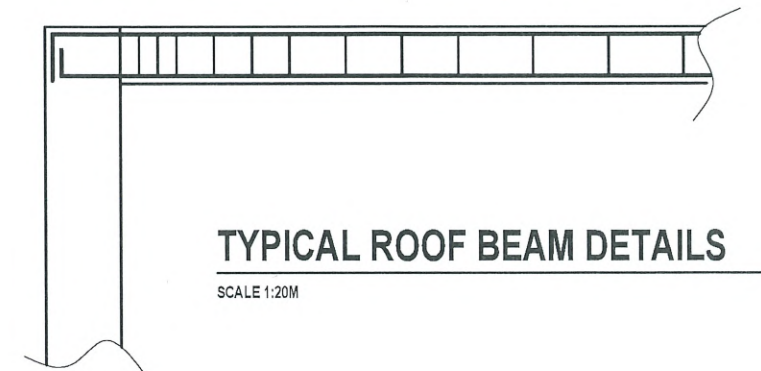


TYPICAL WALL FOOTING DETAILS
SCALE 1:15M

C1 - F1

C1 - F2


TYPICAL COLUMN FOOTING DETAILS
SCALE 1:30M

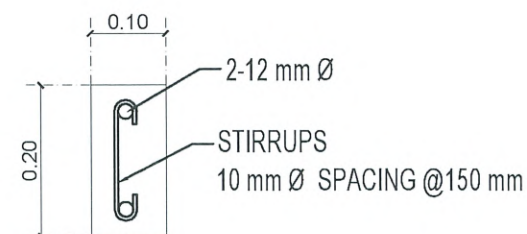

TYPICAL LINTEL BEAM SECTION
SCALE 1:20 MTS.

- FOR OPENINGS:
1. VERIFY ON SITE ALL THE EXISTING SIZES OF DOORS, WINDOWS AND OPENINGS.
 2. ENCLOSE ALL OPENINGS (DOORS, WINDOWS, ACU, ETC.) REQUIRED BY THE PROPOSED PLAN.
- FOR PAINTING WORKS:
1. INTERIOR WALL, CEILING AND COLUMNS SHALL BE REPAINTED.
 2. NEWLY PLASTERED AREA OF EXTERIOR WALLS "REPAIRED" SHALL BE REPAINTED WITH THE SAME EXISTING PAINT COLOR.

SCRAPING OF OLD PAINT ;
REPAINTING OF EXISTING BUILDING
WITH 1 COAT OF PRIMER AND 2
COATS OF SEMI GLOSS LATEX PAINT
(INTERIOR & EXTERIOR)

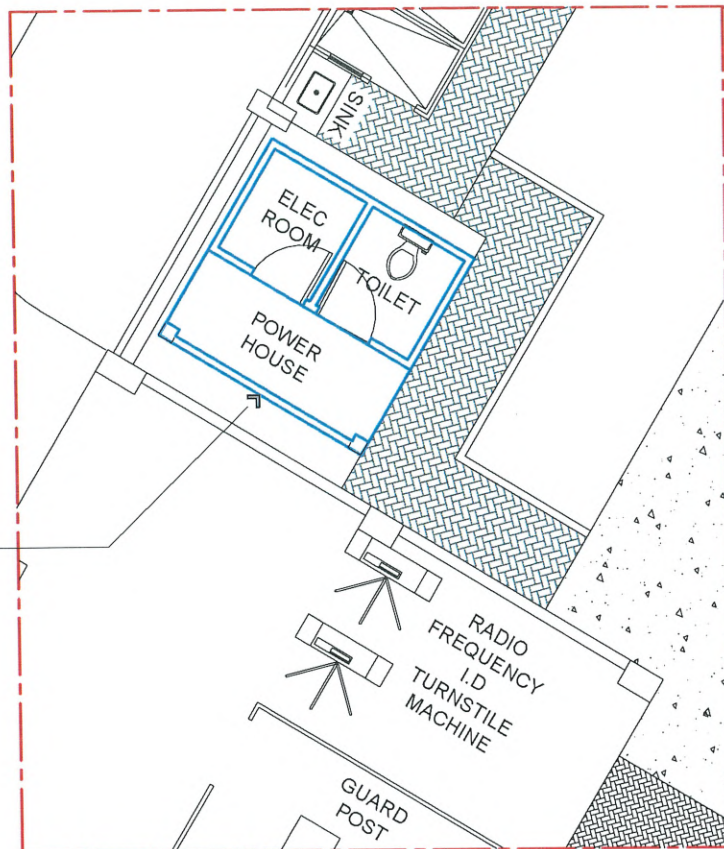


EXISTING CCS POWER HOUSE

SCALE 1:70M



PERSPECTIVE VIEW

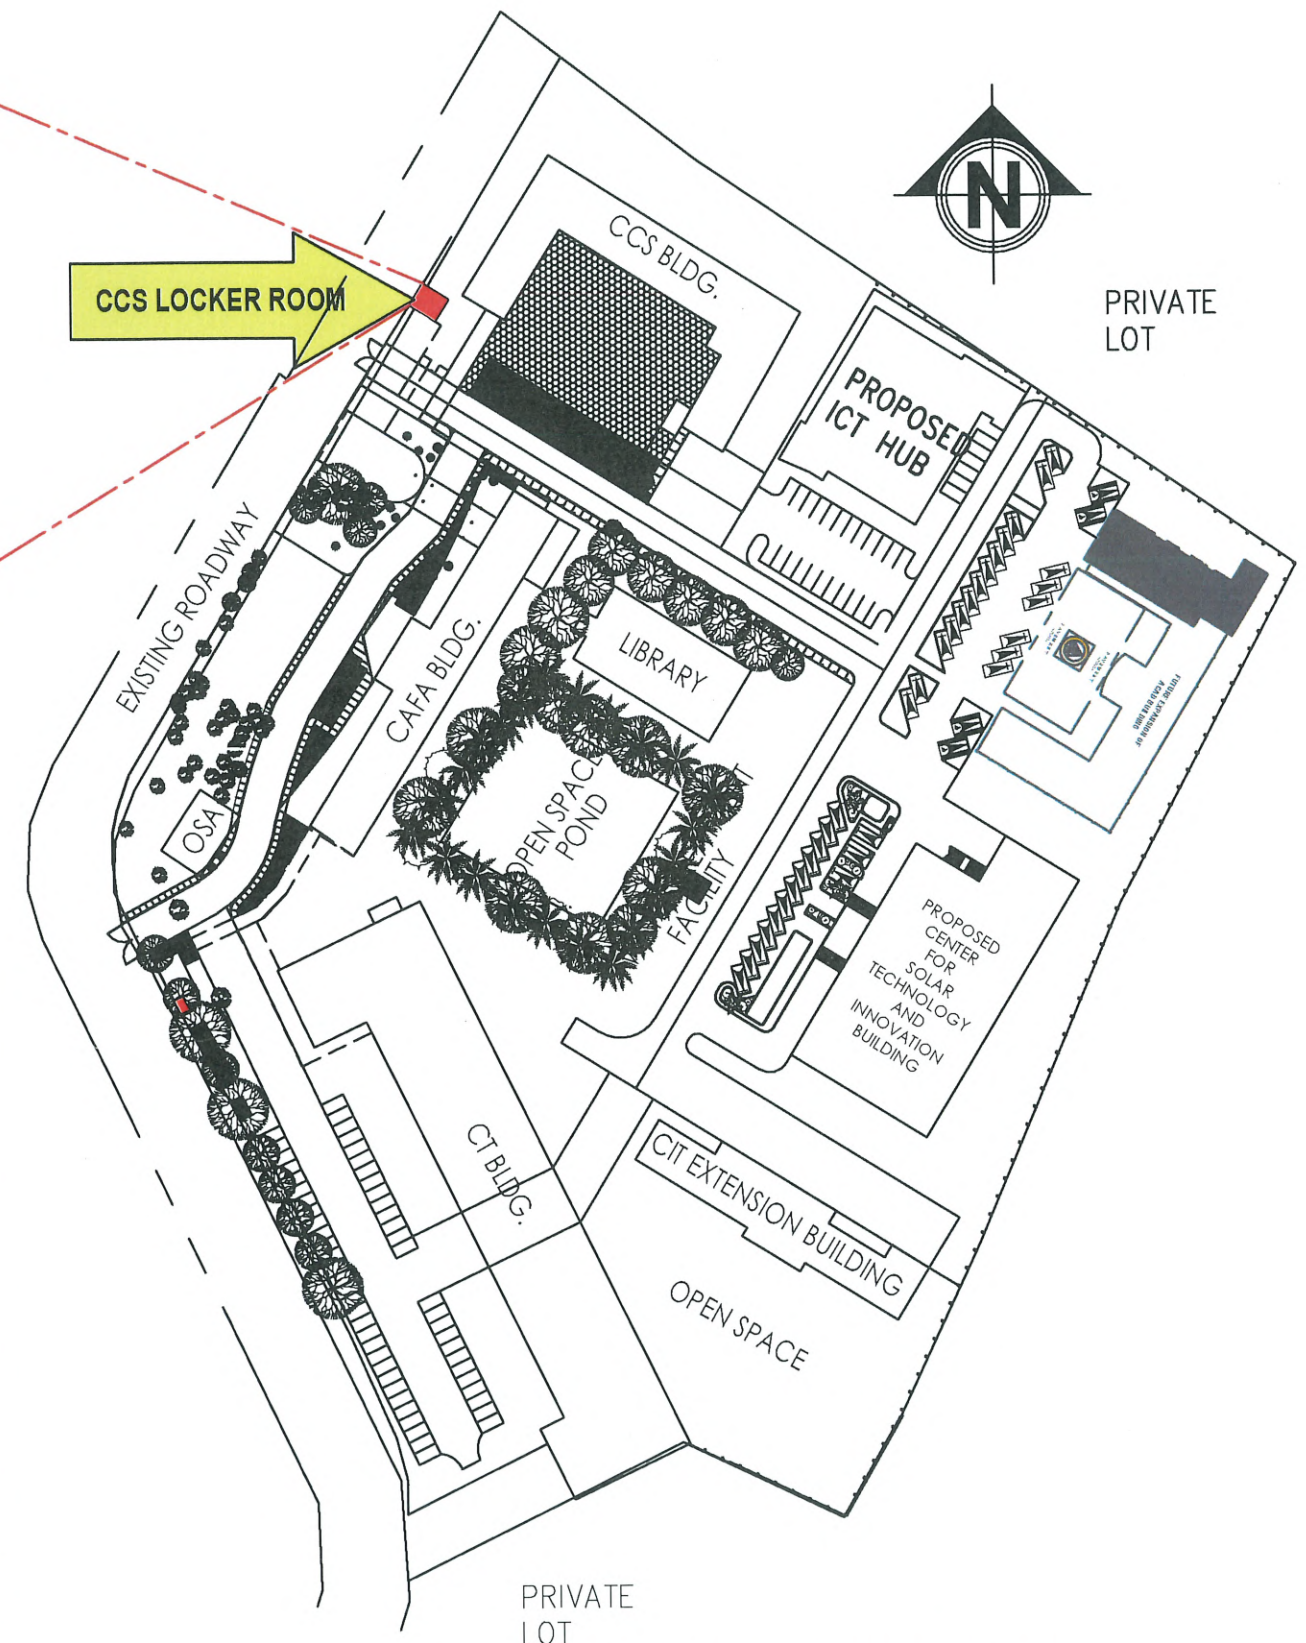


SAN ISIDRO CAMPUS SITE DEVELOPMENT PLAN

SCALE : NTS




TARLAC STATE UNIVERSITY
Facilities Development and
Management Office
Romulo Boulevard, Tarlac City, Philippines 2300

PROJECT TITLE:	PREPARED BY:	CHECKED BY:	CERTIFIED BY:	REQUESTING OFFICE:	RECOMMENDING APPROVAL:	APPROVED:	SHEET CONTENTS:	SHEET NO:
CONSTRUCTION OF SECURITY GUARD LOCKER ROOM	MR. WENCIE S. MANABOG DRAFTSMAN, OFDM-PDU	AR. CHERRY L. FABIANES HEAD, OFDM-PDU	AR. ARLEN M. GUIEB DIRECTOR, OFDM	DR. JAYSON R. FELIX CIVIL SECURITY OFFICER	ATTY. WILMARK J. RAMOS, DBA VP FOR ADMINISTRATION	DR. ARNOLD E. VELASCO PRESIDENT	AS SHOWN	A - 05
PROJECT LOCATION:							DATE: FEBRUARY 2025	PAGE NO: 05/16
SAN ISIDRO & LUCINDA CAMPUS, TARLAC STATE UNIVERSITY								

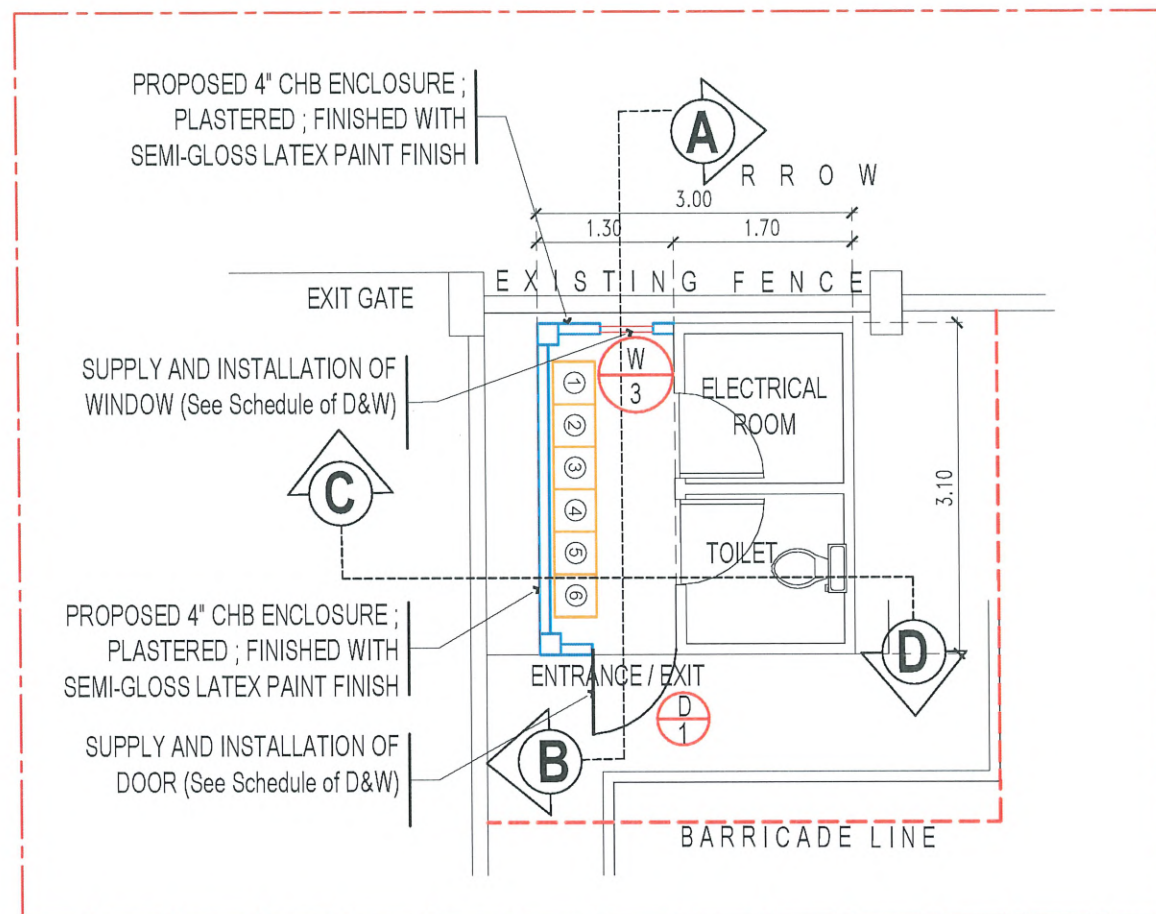


PROPOSED CCS POWER HOUSE WITH LOCKERS

SCALE 1:50M

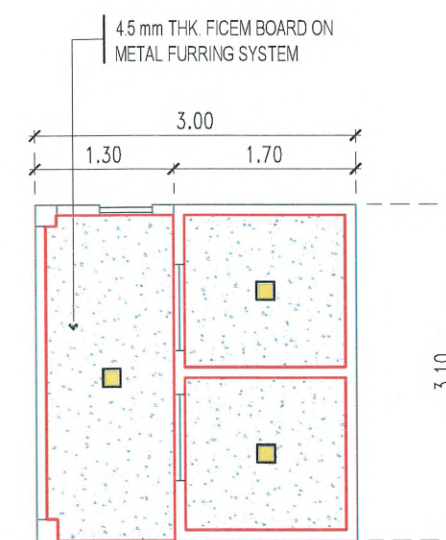


CEILING PLAN

SCALE 1:70M

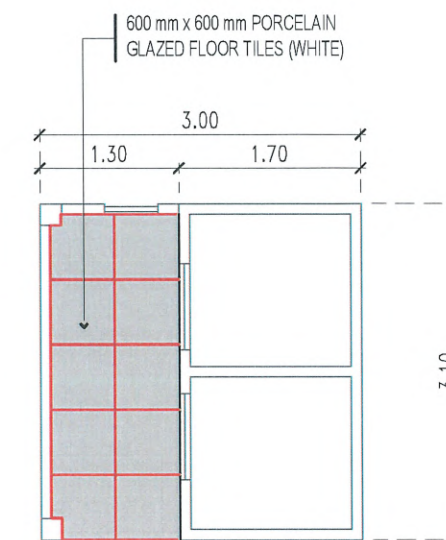


TILE PATTERN

SCALE 1:70M

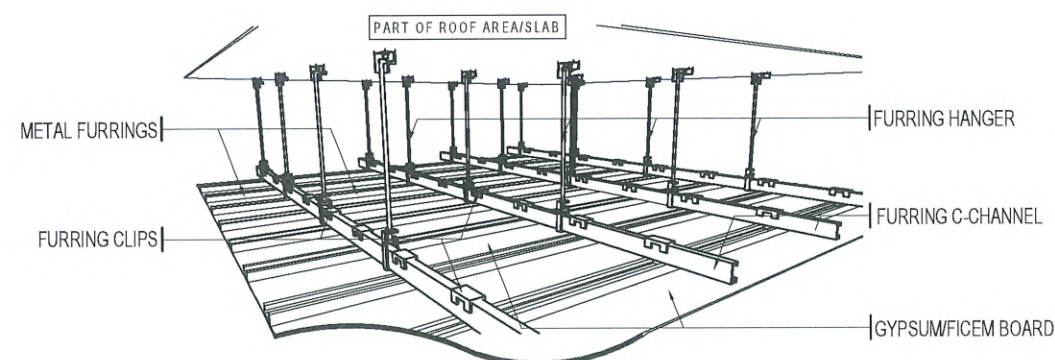


CEILING ISOMETRIC DETAIL

NTS.

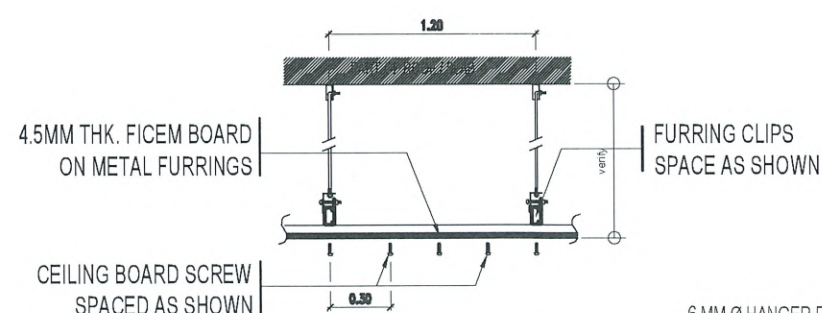

SECTION DETAIL - A

SCALE 1:60MTS.

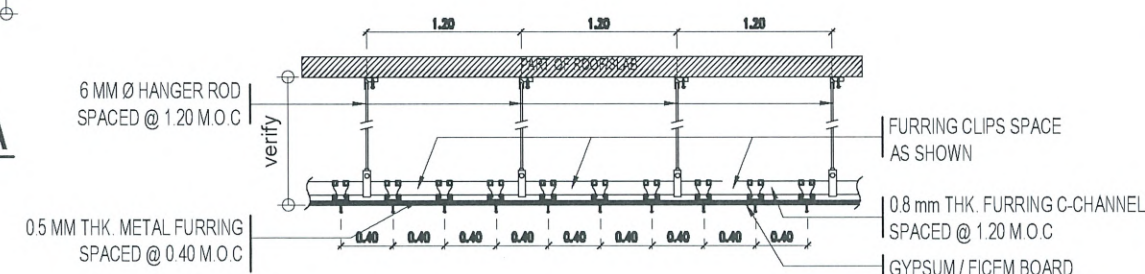

SECTION DETAIL - B


SCALE 1:60MTS.

NOTE :

- USE FLAT LATEX PAINT FINISH FOR ALL FICEM BOARD CEILING


TYPICAL CEILING DETAIL

	TARLAC STATE UNIVERSITY Facilities Development and Management Office Romulo Boulevard, Tarlac City, Philippines 2300	PROJECT TITLE: CONSTRUCTION OF SECURITY GUARD LOCKER ROOM PROJECT LOCATION: SAN ISIDRO & LUCINDA CAMPUS, TARLAC STATE UNIVERSITY	PREPARED BY: MR. WENCIE S. MANABOG DRAFTSMAN, OFDM-PDU	CHECKED BY: AR. CHERRY L. FABIANES HEAD, OFDM-PDU	CERTIFIED BY: AR. ARLEN M. GUIEB DIRECTOR, OFDM	REQUESTING OFFICE: DR. JAYSON R. FELIX CIVIL SECURITY OFFICER	RECOMMENDING APPROVAL: ATTY. WILMARK J. RAMOS, DBA VP FOR ADMINISTRATION	APPROVED: DR. ARNOLD E. VELASCO PRESIDENT	SHEET CONTENTS: AS SHOWN DATE: FEBRUARY 2025 SHEET NO: A - 06 PAGE NO: 06/16
--	---	--	--	---	---	---	--	---	--

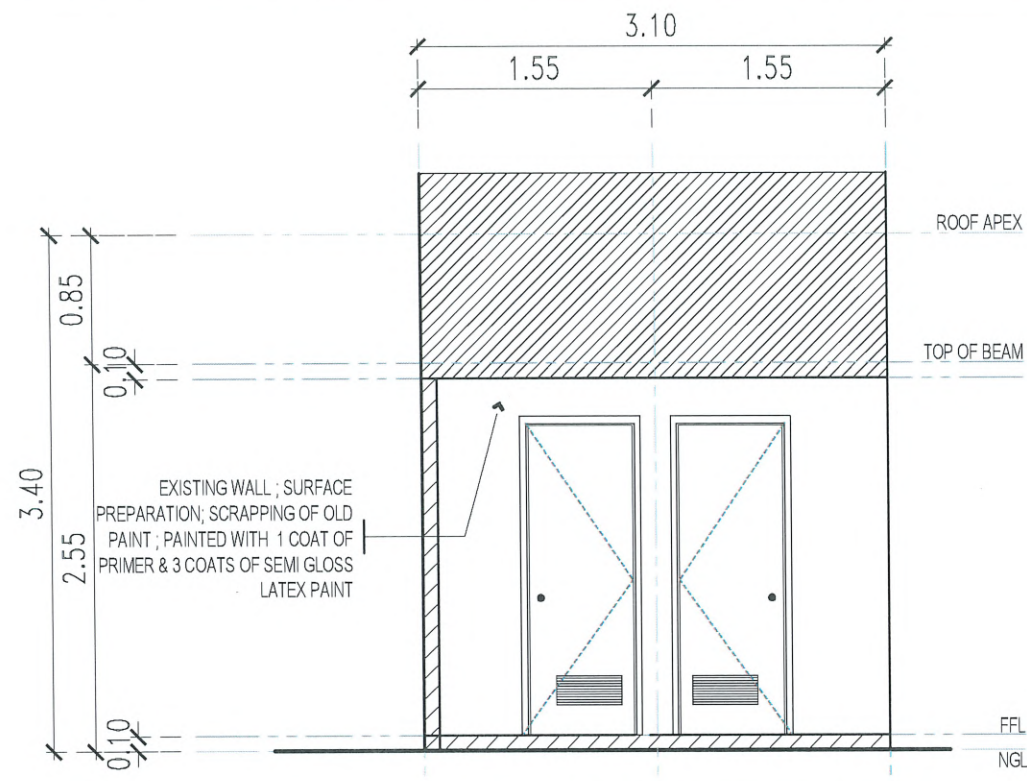


SECTION - A

SCALE 1:50M

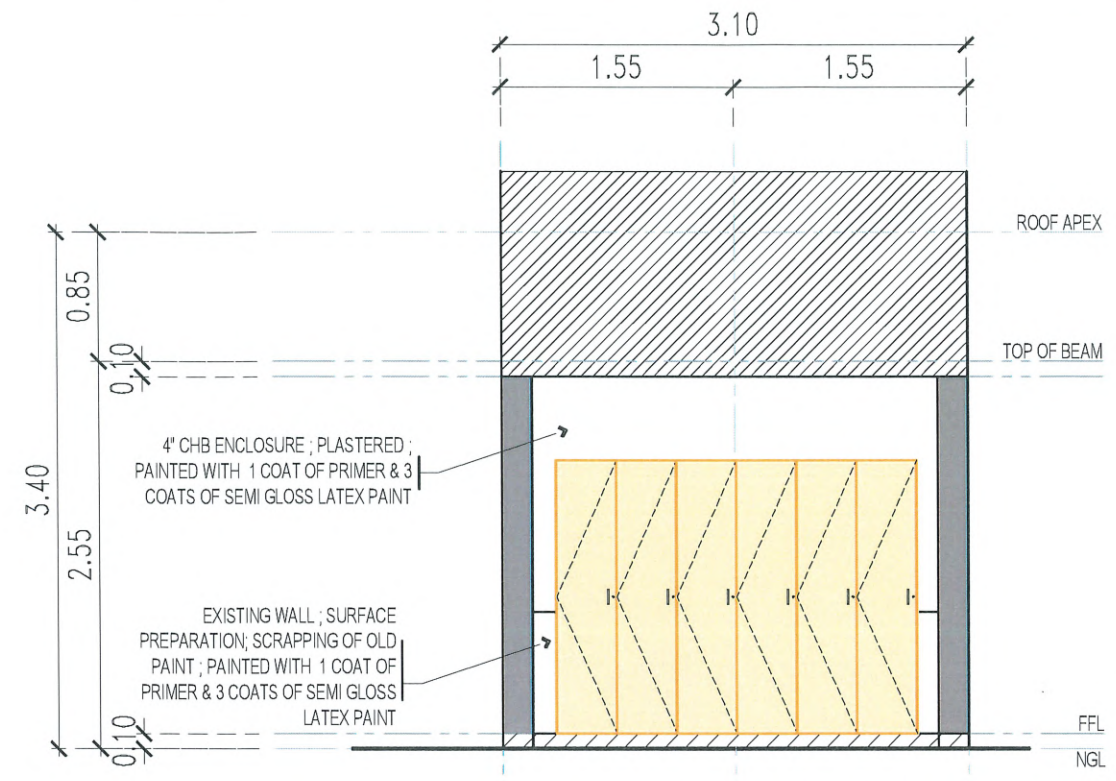


SECTION - B

SCALE 1:50M

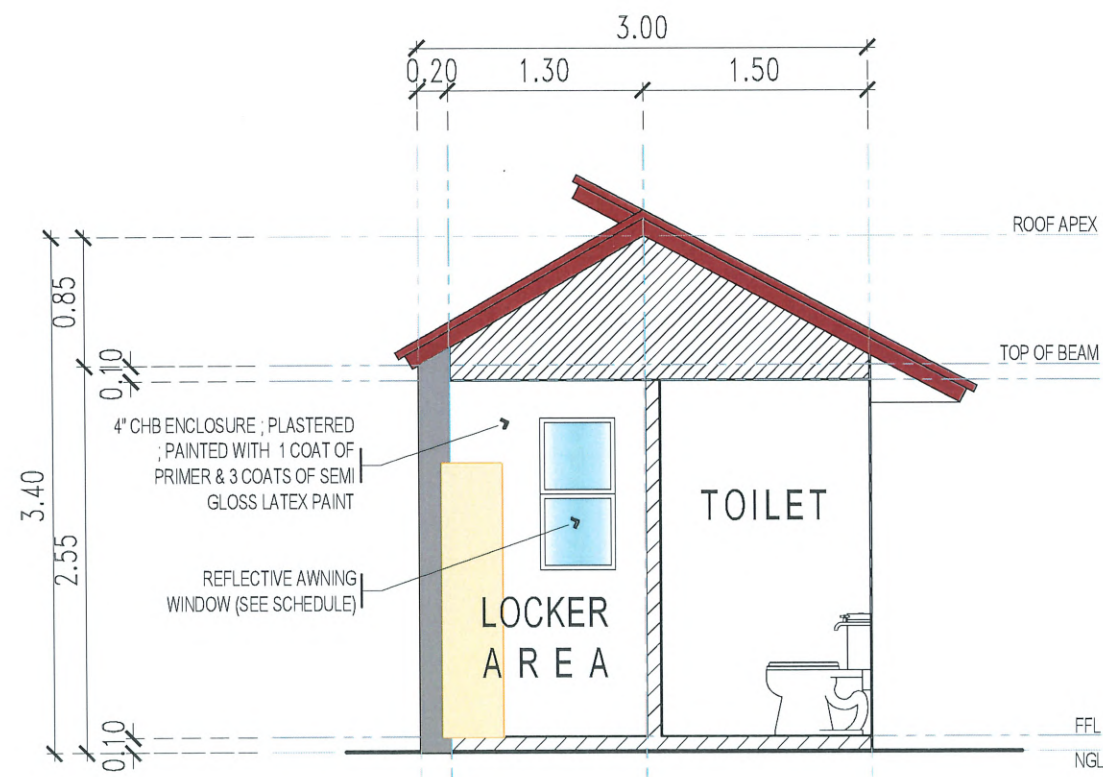

SECTION - C

SCALE 1:50M

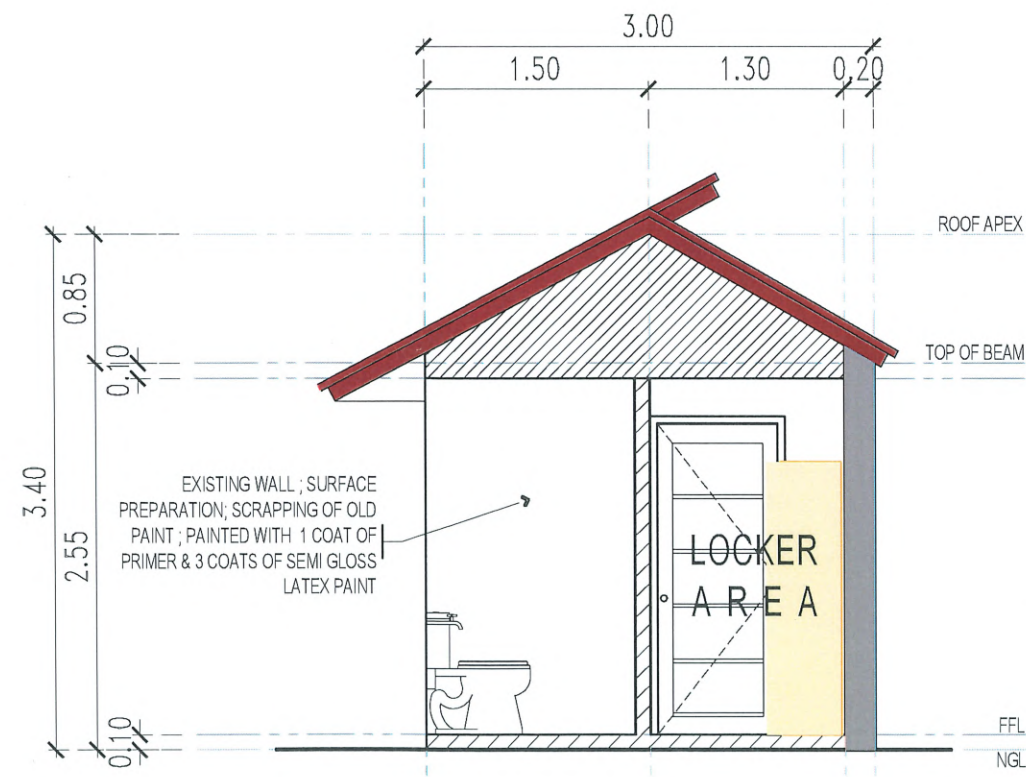

SECTION - D

SCALE 1:50M

NOTE :

1. SURFACE PREPARATION; SCRAPPING OF OLD PAINT & APPLICATION OF BODY-FILLER IN ALL UNEVEN SURFACES.
2. REPAINTING OF EXTERIOR AND INTERIOR WALLS OF LOCKER ROOM.
3. APPLY 1 COAT OF PRIMER & 2 COATS OF SEMI GLOSS LATEX PAINT (TULLE WHITE)
4. ALL PROPOSED WALL MUST HAVE WALL FOOTING.
5. PROVIDE TEMPORARY BARRICADE/ COVER WITHIN THE CONSTRUCTION AREA/ROOM USING PLYWOOD/G.I. SHEET WITH STABLE FRAME AND INCLUDE SAFETY SIGNAGES. DO NOT USE "BLUE SACK" AS COVER.



TARLAC STATE UNIVERSITY
Facilities Development and
Management Office
Romulo Boulevard, Tarlac City, Philippines 2300

PROJECT TITLE:
CONSTRUCTION OF SECURITY GUARD LOCKER ROOM
PROJECT LOCATION:
SAN ISIDRO & LUCINDA CAMPUS,
TARLAC STATE UNIVERSITY

PREPARED BY:

MR. WENSIE S. MANABOG
DRAFTSMAN, OFDM-PDU

CHECKED BY:

AR. CHERRY L. FABIANES
HEAD, OFDM-PDU

CERTIFIED BY:

AR. ARLEN M. GUIEB
DIRECTOR, OFDM

REQUESTING OFFICE:

DR. JAYSON R. FELIX
CIVIL SECURITY OFFICER

RECOMMENDING APPROVAL:

ATTY. WILMARK J. RAMOS, DBA
VP FOR ADMINISTRATION

APPROVED:


DR. ARNOLD E. VELASCO
PRESIDENT

SHEET CONTENTS:
AS SHOWN
DATE: FEBRUARY 2025

SHEET NO:
A - 07
PAGE NO:
07/16




PERSPECTIVE VIEW

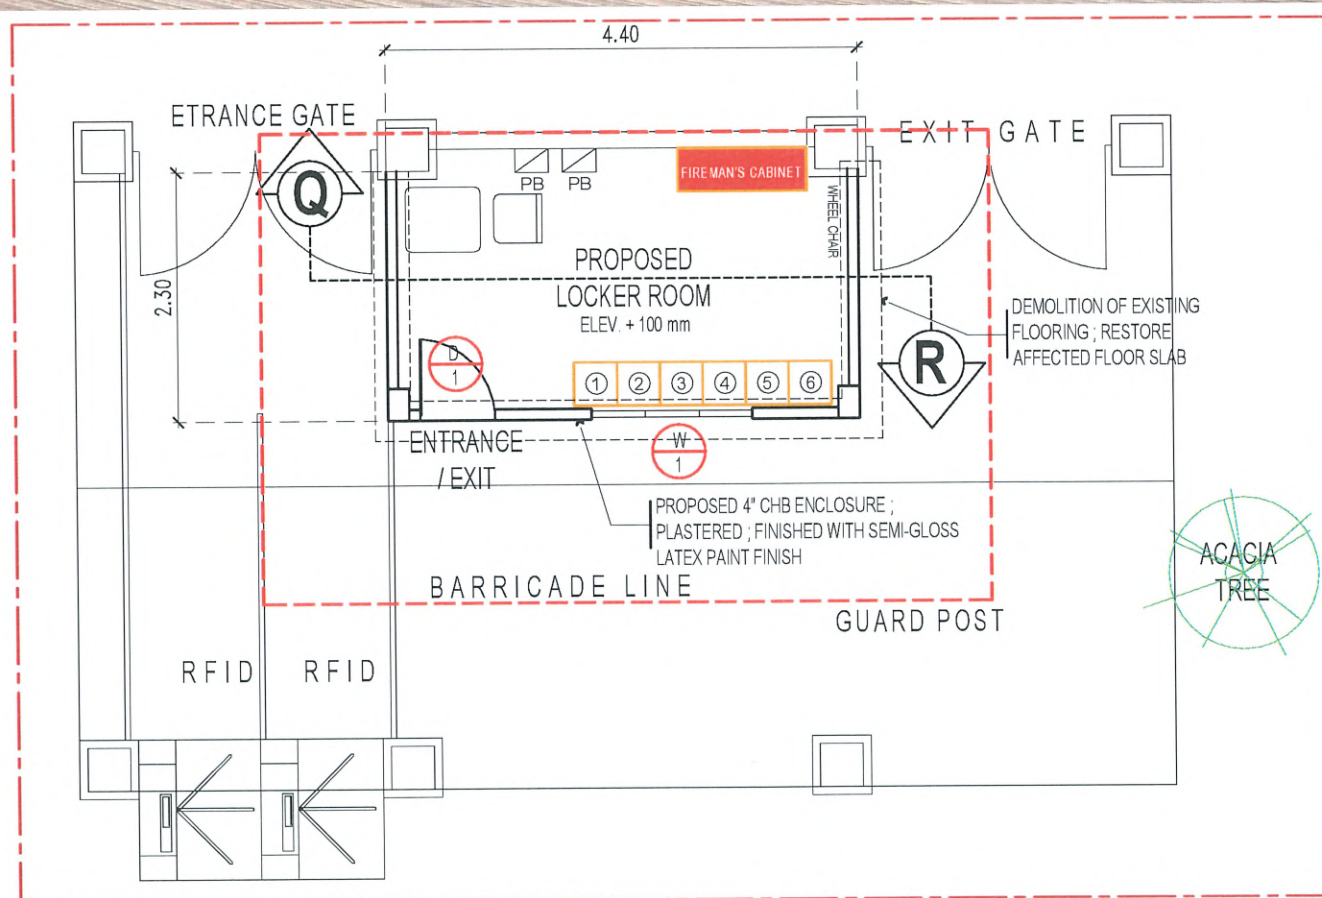

PROPOSED LUCINDA GATE 1 LOCKER ROOM


SCALE 1:70M

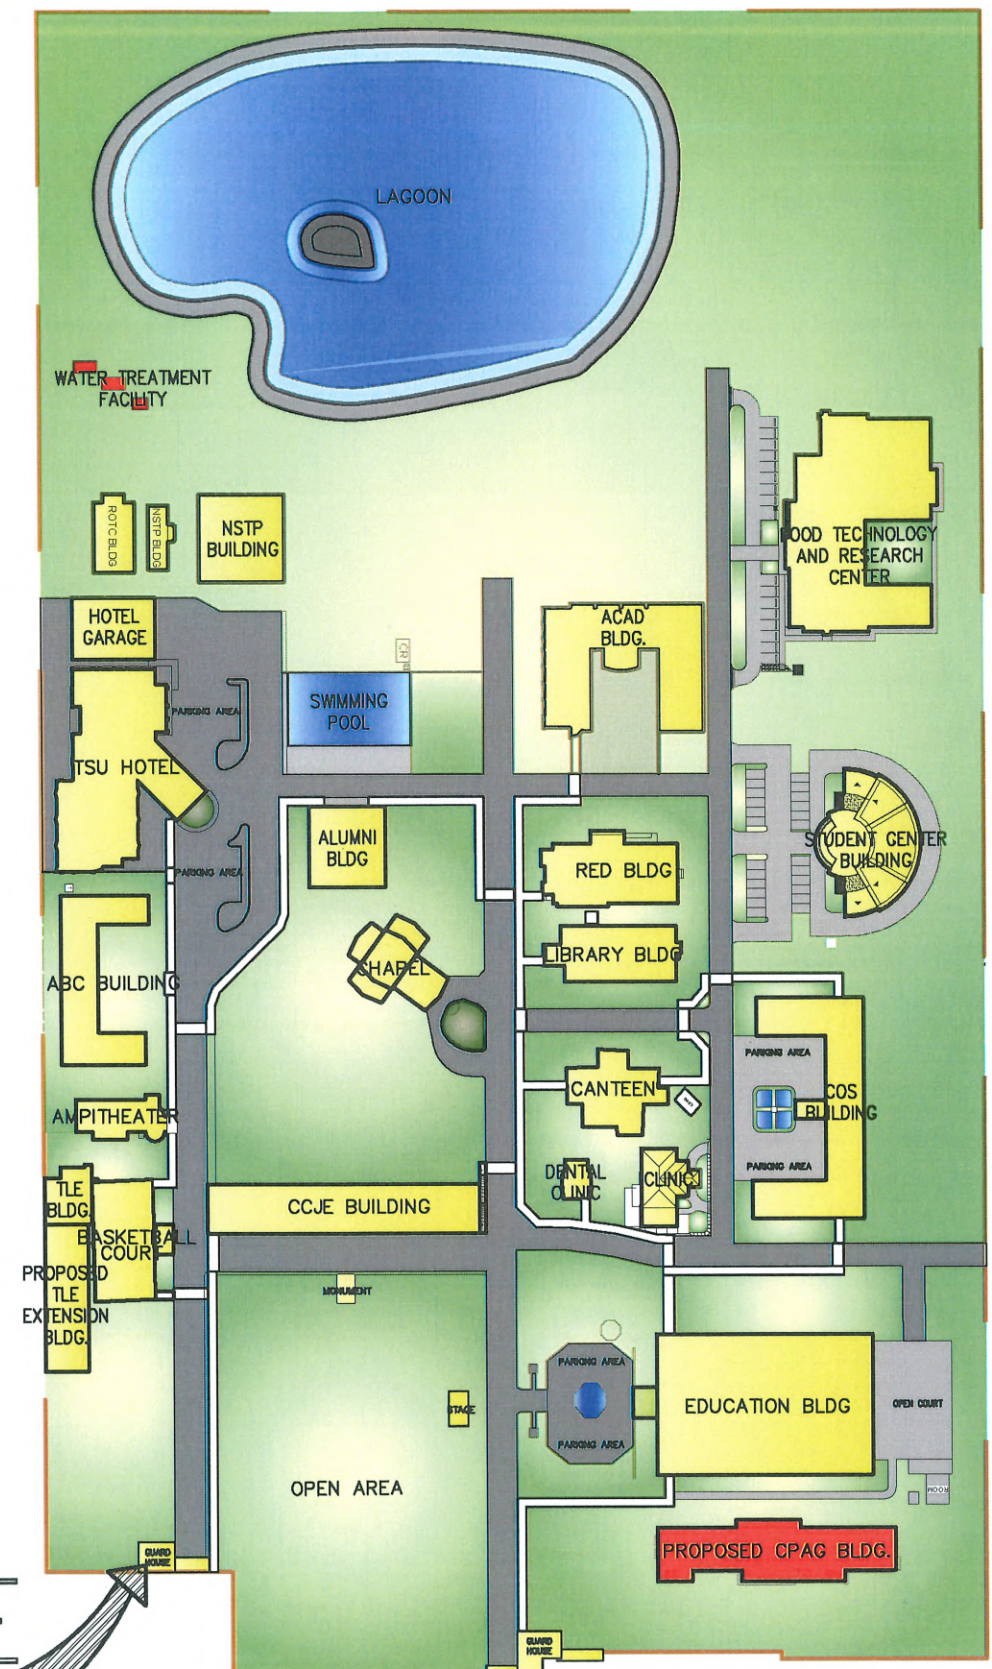

LOCATION MAP


SCALE 1:2000

 TARLAC STATE UNIVERSITY Facilities Development and Management Office Romulo Boulevard, Tarlac City, Philippines 2300	PROJECT TITLE: CONSTRUCTION OF SECURITY GUARD LOCKER ROOM PROJECT LOCATION: SAN ISIDRO & LUCINDA CAMPUS, TARLAC STATE UNIVERSITY	PREPARED BY:  MR. WENSIE S. MANIBON DRAFTSMAN, OFDM-PDU	CHECKED BY:  AR. CHERRY L. FABIANES HEAD, OFDM-PDU	CERTIFIED BY:  AR. ARLEN M. GUIEB DIRECTOR, OFDM	REQUESTING OFFICE:  DR. JAYSON R. FELIX CIVIL SECURITY OFFICER	RECOMMENDING APPROVAL:  ATTY. WILMARK J. RAMOS, DBA VP FOR ADMINISTRATION	APPROVED:  DR. ARNOLD E. VELASCO PRESIDENT	SHEET CONTENTS: AS SHOWN DATE: FEBRUARY 2025	SHEET NO: A - 08 PAGE NO: 08/16
---	--	---	--	--	--	---	--	--	--

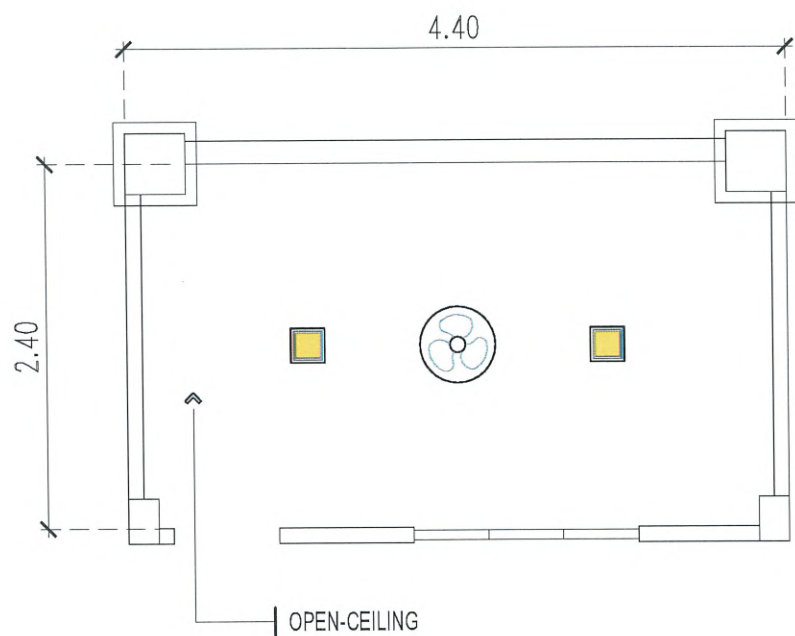


REFLECTED CEILING PLAN

SCALE 1:50M

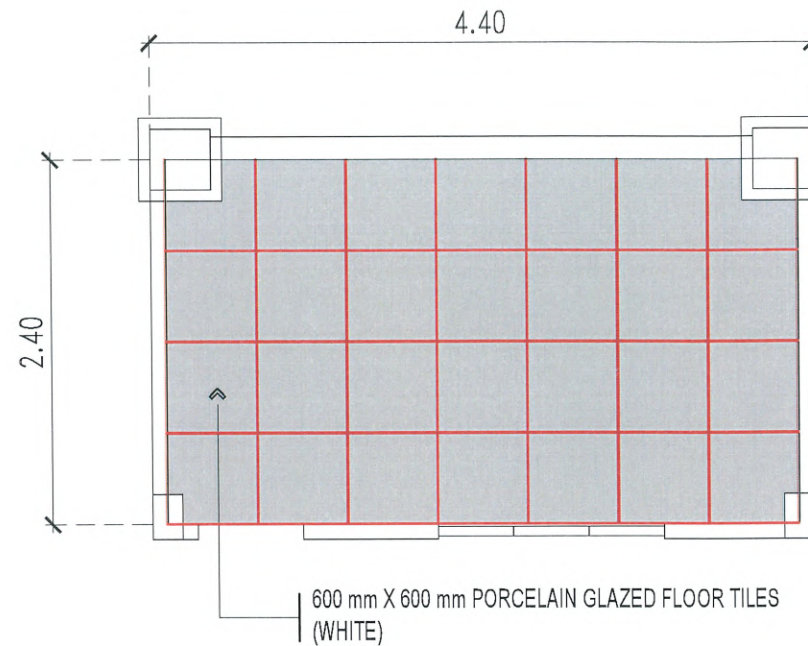


TILE PATTERN

SCALE 1:50M

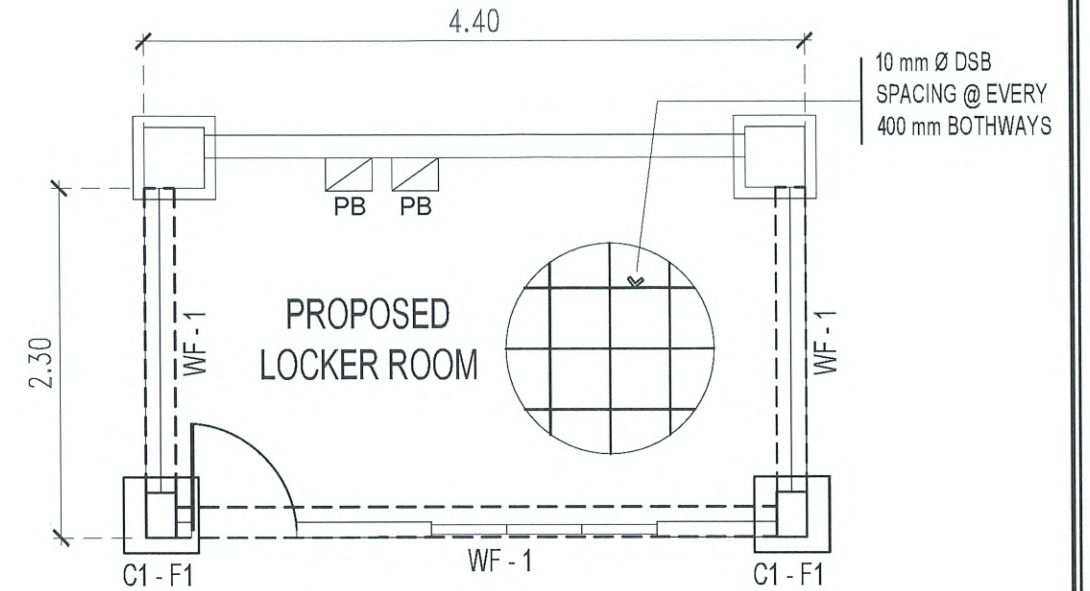


FOUNDATION PLAN

SCALE 1:50M

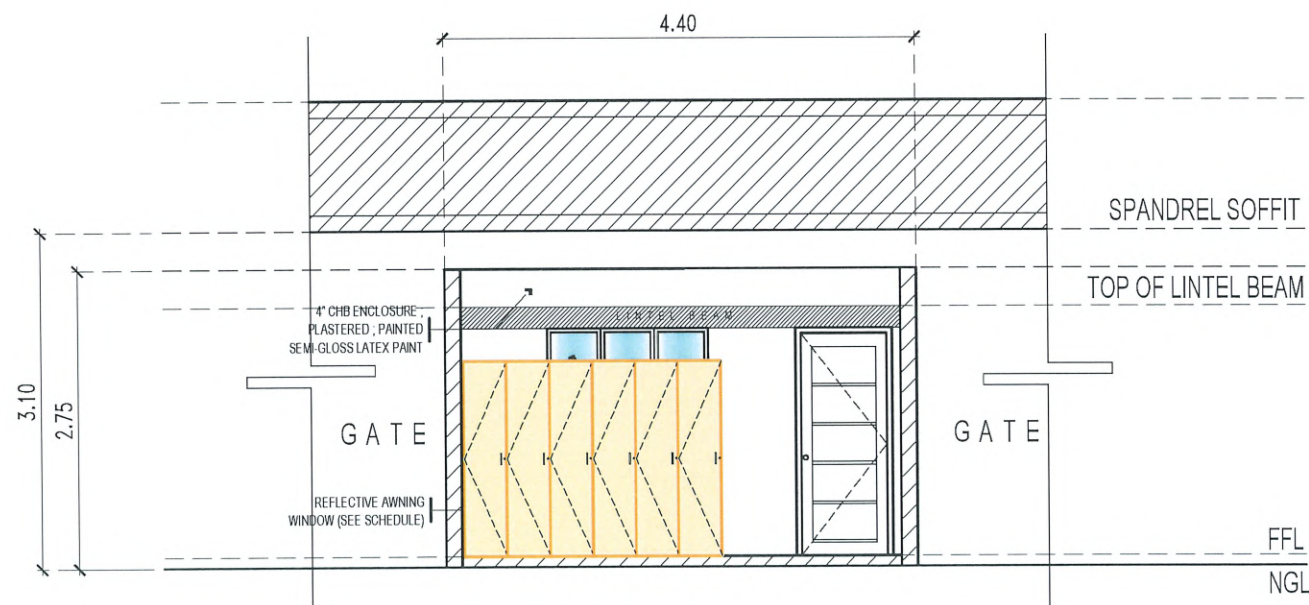

SECTION THRU - R

SCALE 1:70M

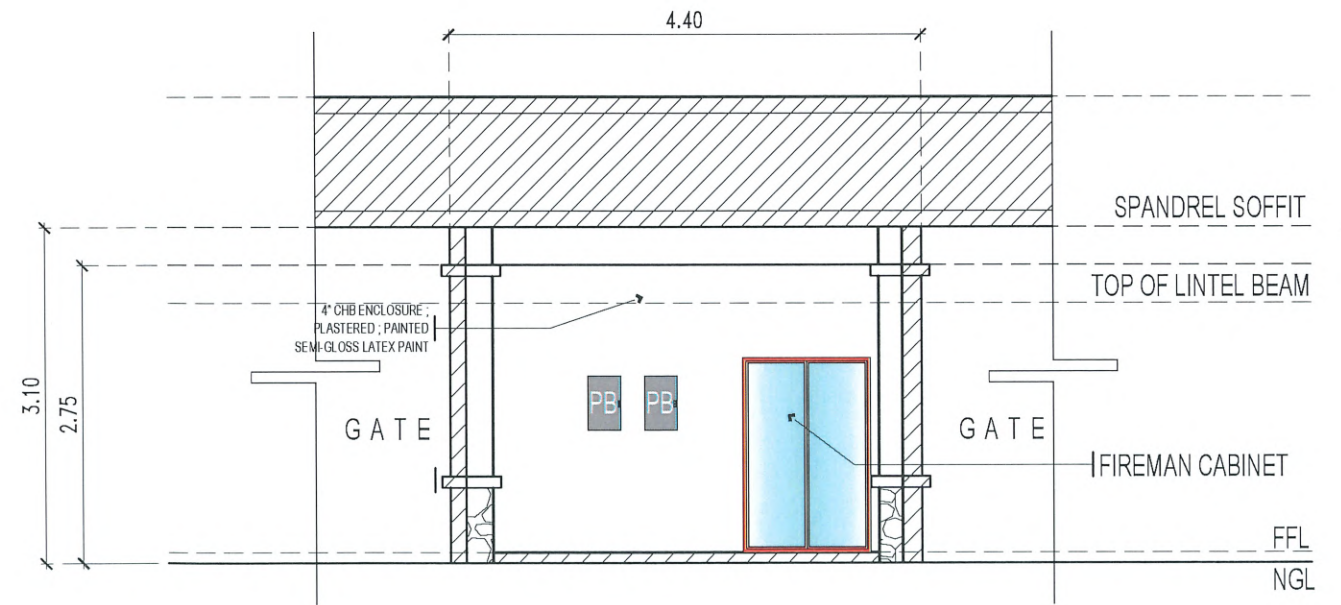

SECTION THRU - Q

SCALE 1:70M



TARLAC STATE UNIVERSITY
Facilities Development and
Management Office
Romulo Boulevard, Tarlac City, Philippines 2300

PROJECT TITLE:
CONSTRUCTION OF SECURITY GUARD LOCKER ROOM
PROJECT LOCATION:
SAN ISIDRO & LUCINDA CAMPUS,
TARLAC STATE UNIVERSITY

PREPARED BY:

MR. WENCES MANABOG
DRAFTSMAN, OFDM-PDU

CHECKED BY:

AR. CHERRY L. FABIANES
HEAD, OFDM-PDU

CERTIFIED BY:

AR. ARLEN M. GUIEB
DIRECTOR, OFDM

REQUESTING OFFICE:

DR. JAYSON R. FELIX
CIVIL SECURITY OFFICER

RECOMMENDING APPROVAL:

ATTY. WILMARK J. RAMOS, DBA
VP FOR ADMINISTRATION


APPROVED:

DR. ARNOLD E. VELASCO
PRESIDENT

SHEET CONTENTS:
AS SHOWN
DATE: FEBRUARY 2025

SHEET NO:
A - 09
PAGE NO:
09/16

- NOTE :
- 1. FABRICATION OF 24 SETS OF LOCKER.
 - 2. ALL LOCKERS MUST BE WELL TREATED WITH ANTI-TERMITE SOLUTION.
 - 3. FINISH ALL $\frac{3}{4}$ " MARINE PLYWOOD WITH WOOD EDGING
 - 4. FINISHED WITH 3 COATS OF PAINT (WHITE)

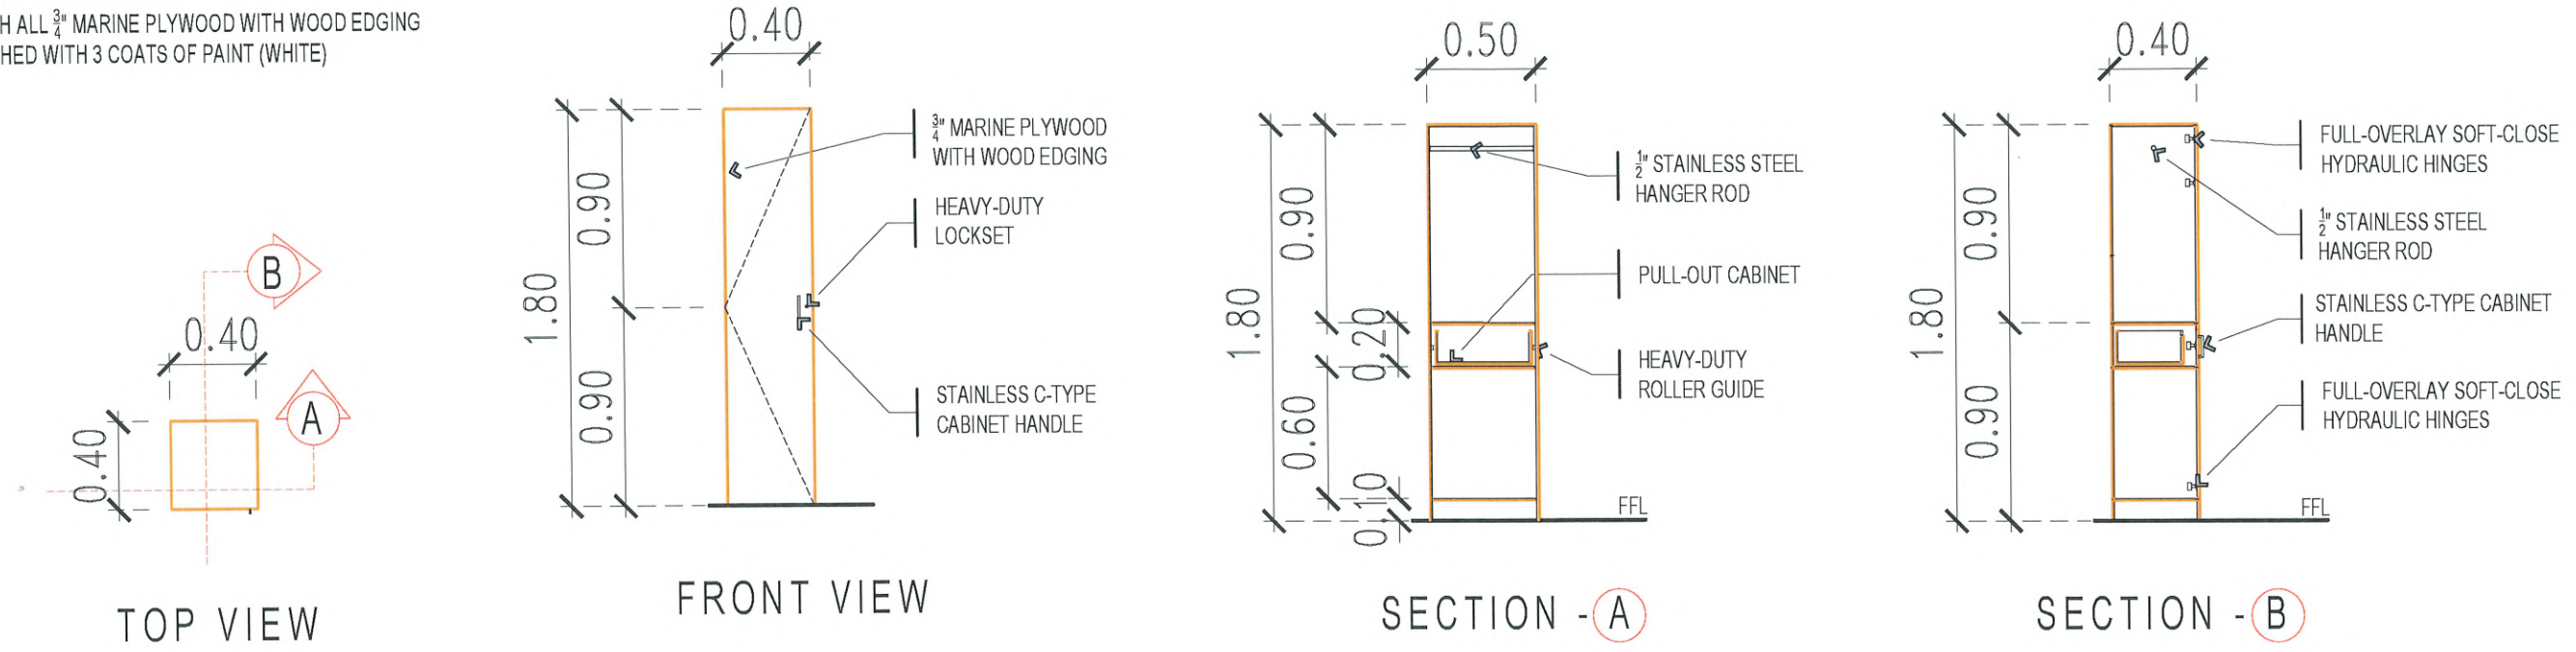


TYPICAL LOCKER DETAILS
SCALE 1:60M

SCHEDULE OF DOOR & WINDOW SCALE 1:80M												
	F.F.L.		F.F.L.		F.F.L.		F.F.L.		F.F.L.		F.F.L.	
	QUANTITY:	4 SETS	QUANTITY:	1 SET	QUANTITY:	1 SET	QUANTITY:	1 SETS	QUANTITY:	2 SETS	QUANTITY:	1 SET
	LOCATION:	CAFA & CCS LOCKER ROOM, LUCINDA GATE 1&2 LOCKER ROOM	LOCATION:	LUCINDA GATE 2 LOCKER ROOM TOILET	LOCATION:	LUCINDA GATE 1 LOCKER ROOM	LOCATION:	CAFA GUARD LOCKER ROOM	LOCATION:	CAFA AND CCS GUARD LOCKER ROOM	LOCATION:	LUCINDA GATE 2 LOCKER ROOM TOILET
DESCRIPTION:	TANGLE SINGLE SWING PANEL DOOR (WOOD STAIN FINISH) JAMB : 1.30MM THK STEEL JAMB (WOOD STAIN FINISH) DOOR KNOB: HEAVY DUTY, DOME TYPE HINGES: HEAVY DUTY STAINLESS		TANGLE SINGLE SWING PANEL DOOR W/ LOUVER (WOOD STAIN FINISH) JAMB : 0.50MM THK STEEL JAMB (WOOD STAIN FINISH) DOOR KNOB: HEAVY DUTY, DOME TYPE HINGES: HEAVY DUTY STAINLESS		WHITE POWDER COATED ALUMINUM AWNING WINDOW WITH 6mm THK. ONE WAY REFLECTIVE BRONZE TEMPERED GLASS (exterior) WITH COMPLETE ACCESSORIES		WHITE POWDER COATED ALUMINUM AWNING WINDOW WITH 6mm THK. ONE WAY REFLECTIVE BRONZE TEMPERED GLASS (exterior) WITH COMPLETE ACCESSORIES		WHITE POWDER COATED ALUMINUM AWNING WINDOW WITH 6mm THK. ONE WAY REFLECTIVE BRONZE TEMPERED GLASS (exterior) WITH COMPLETE ACCESSORIES		WHITE POWDER COATED ALUMINUM SLIDING WINDOW WITH 6mm THK. ONE WAY REFLECTIVE BRONZE TEMPERED GLASS (exterior) WITH COMPLETE ACCESSORIES	




PERSPECTIVE VIEW

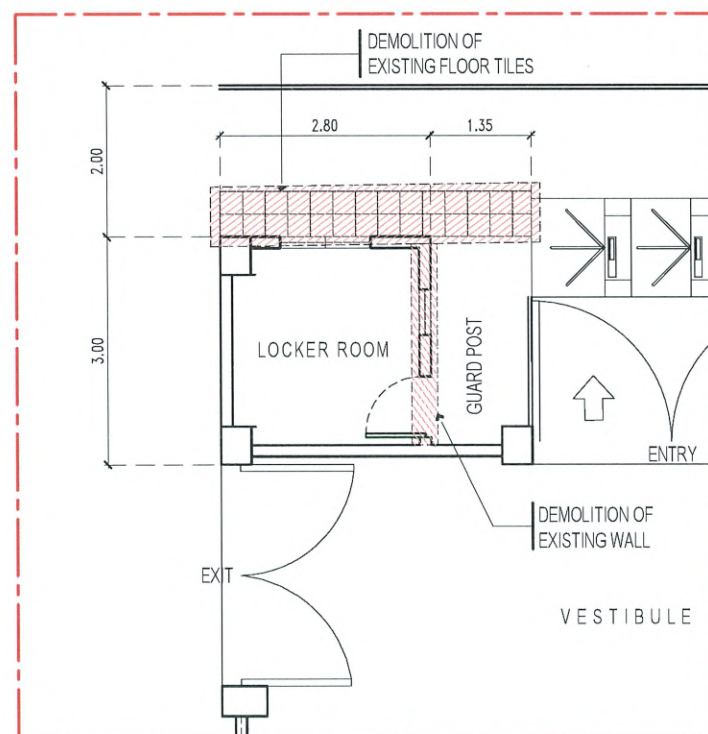

EXISTING LUCINDA GATE 2 GUARD HOUSE

SCALE 1:100M

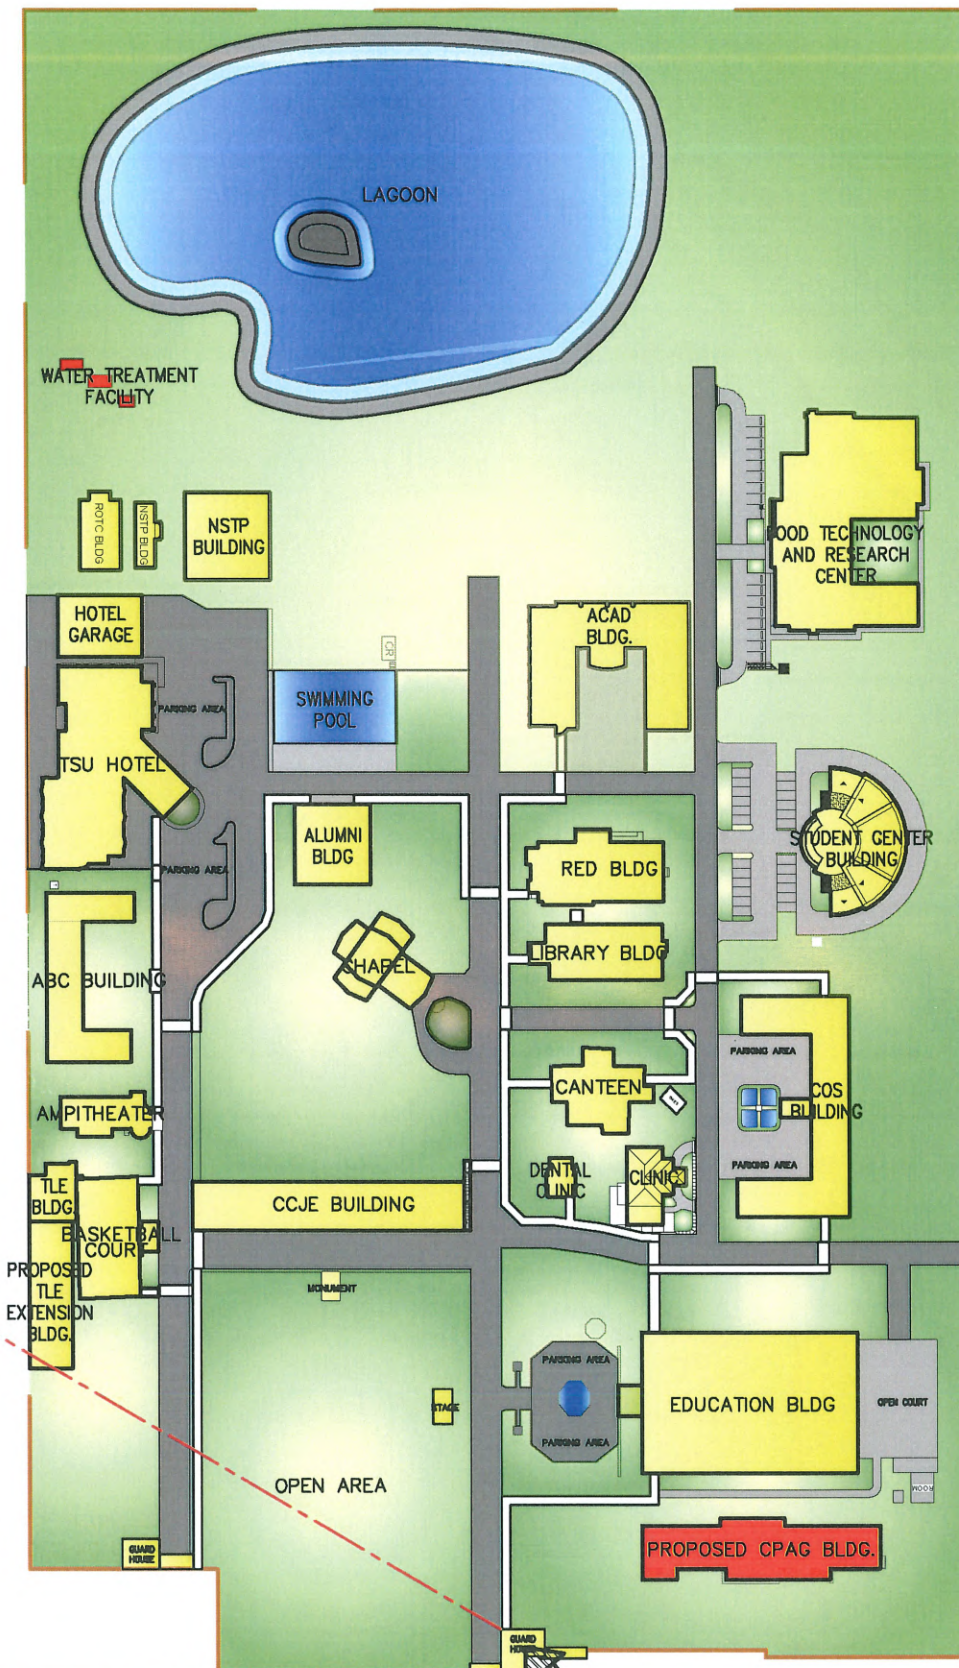

LOCATION MAP

SCALE 1:2000

SITE



TARLAC STATE UNIVERSITY
Facilities Development and
Management Office
Romulo Boulevard, Tarlac City, Philippines 2300

PROJECT TITLE:
CONSTRUCTION OF SECURITY GUARD LOCKER ROOM
PROJECT LOCATION:
SAN ISIDRO & LUCINDA CAMPUS,
TARLAC STATE UNIVERSITY

PREPARED BY:

MR. WENCEL S. MANABOG
DRAFTSMAN, OFDM-PDU

CHECKED BY:

AR. CHERRY L. FABIANES
HEAD, OFDM-PDU

CERTIFIED BY:

AR. ARLEN M. GUIEB
DIRECTOR, OFDM

REQUESTING OFFICE:

DR. JAYSON R. FELIX
CIVIL SECURITY OFFICER

RECOMMENDING APPROVAL:


ATTY. WILMARK J. RAMOS, DBA
VP FOR ADMINISTRATION

APPROVED:


DR. ARNOLD E. VELASCO
PRESIDENT

SHEET CONTENTS:
AS SHOWN
DATE: FEBRUARY 2025


SHEET NO.:
A - 11
PAGE NO.:
11/16

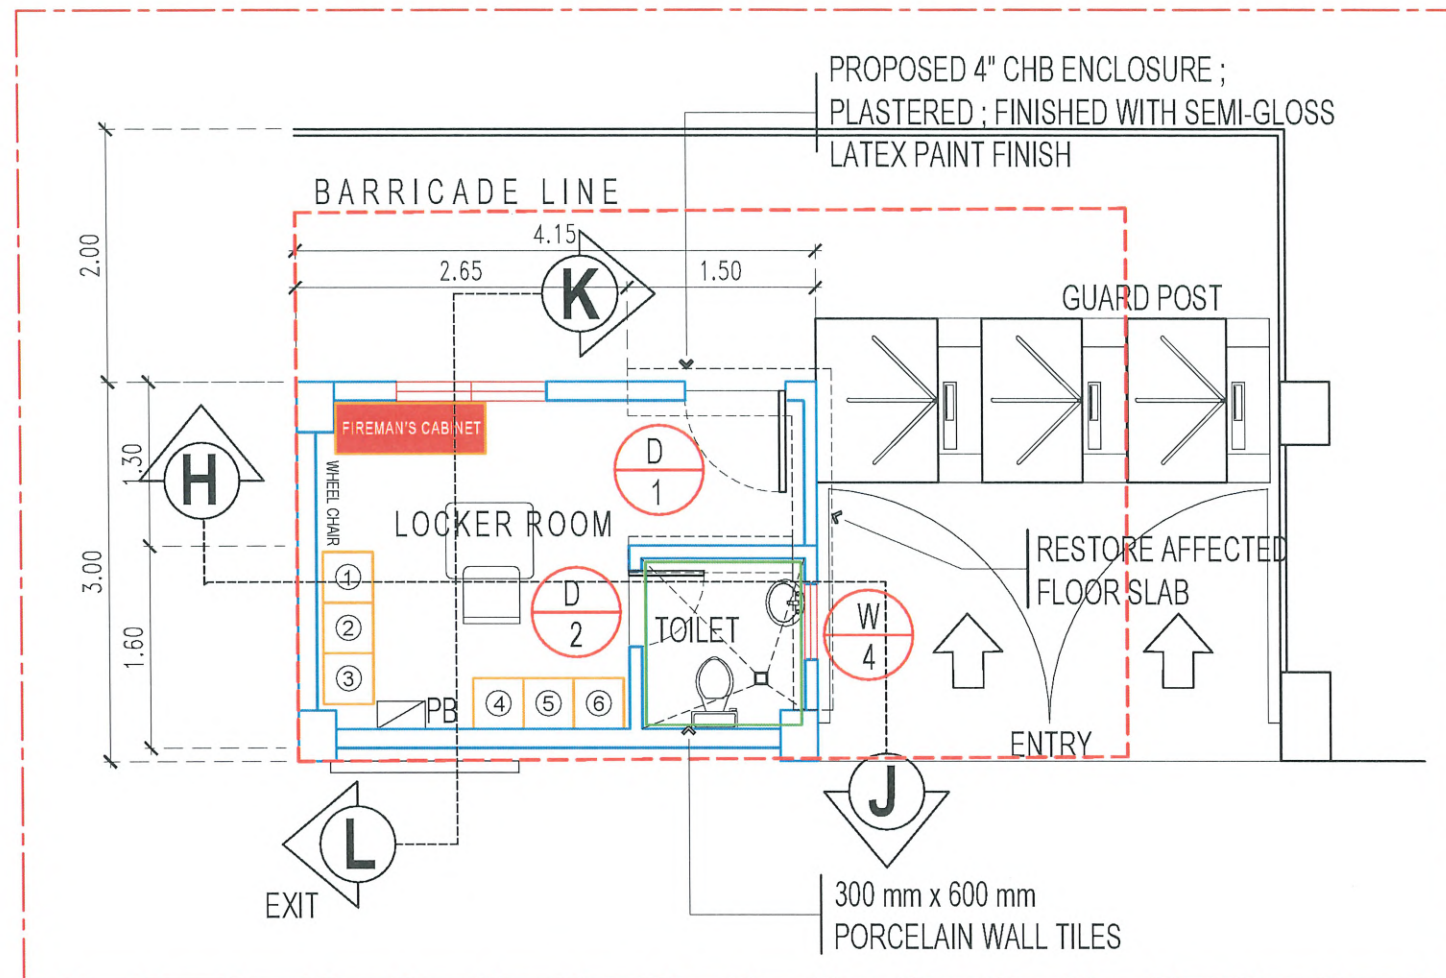


PROPOSED LUCINDA GATE 2 GUARD HOUSE LOCKER ROOM
SCALE 1:60M

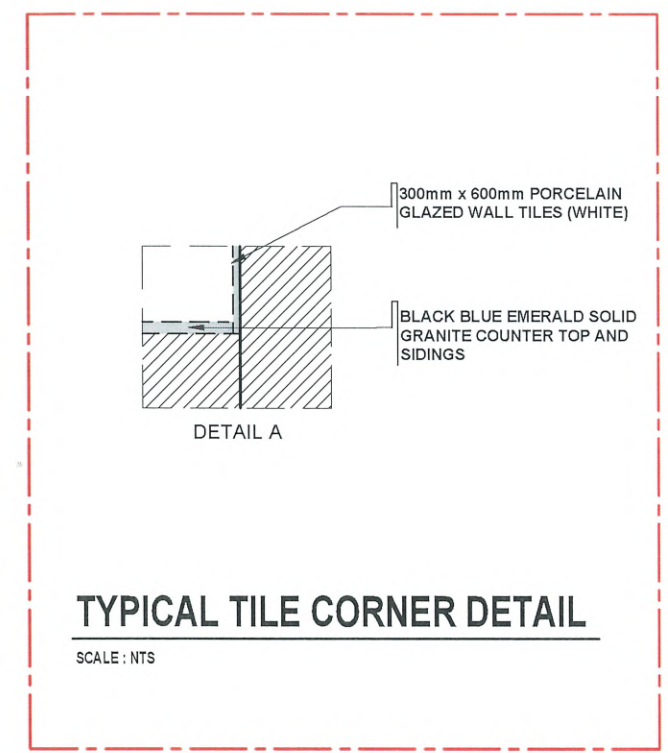

- NOTE :
1. SURFACE PREPARATION; SCRAPING OF OLD PAINT & APPLICATION OF BODY-FILLER IN ALL UNEVEN SURFACES.
 2. REPAINTING OF EXTERIOR AND INTERIOR WALLS OF LOCKER ROOM.
 3. APPLY 1 COAT OF PRIMER & 2 COATS OF SEMI GLOSS LATEX PAINT (TULLE WHITE)
 4. ALL PROPOSED WALL MUST HAVE WALL FOOTING.
 5. PROVIDE TEMPORARY BARRICADE/ COVER WITHIN THE CONSTRUCTION AREA/ROOM USING PLYWOOD/G.I. SHEET WITH STABLE FRAME AND INCLUDE SAFETY SIGNAGES. DO NOT USE "BLUE SACK" AS COVER.



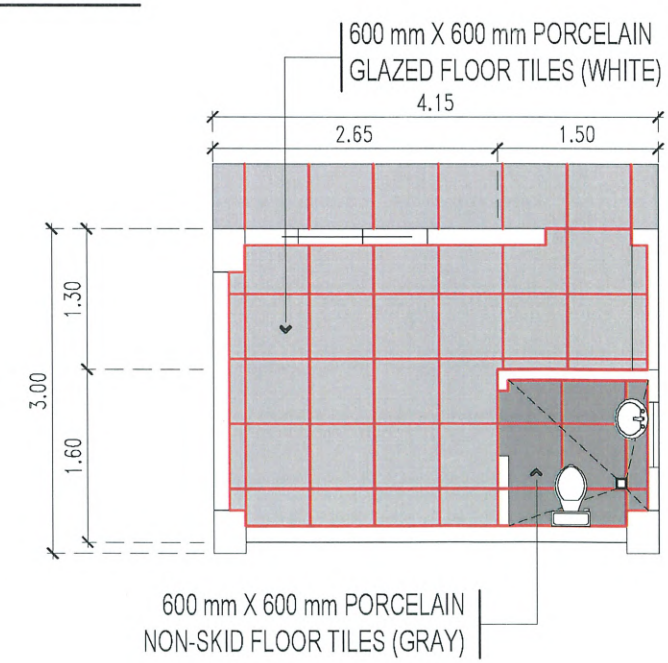



FLOOR TILE PATTERN
SCALE 1:70M

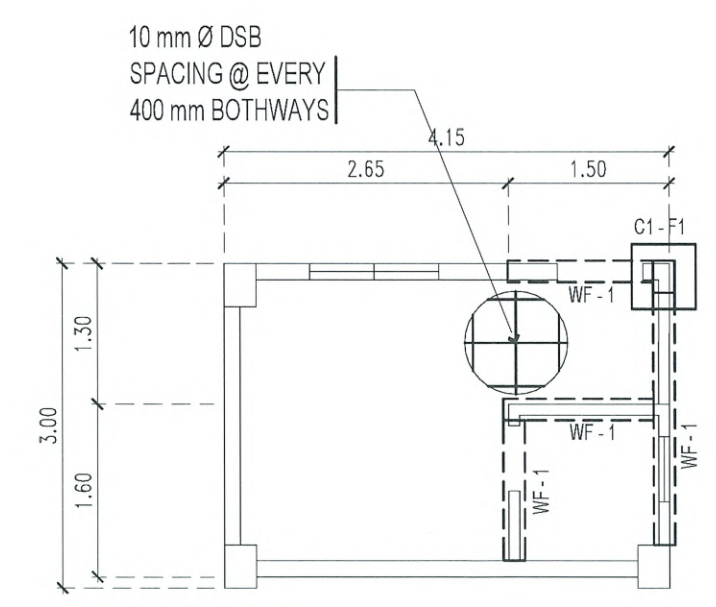

FOUNDATION PLAN
SCALE 1:70M

   
CEILING PLAN
SCALE 1:70M

 TARLAC STATE UNIVERSITY Facilities Development and Management Office Romulo Boulevard, Tarlac City, Philippines 2300	PROJECT TITLE:	PREPARED BY:	CHECKED BY:	CERTIFIED BY:	REQUESTING OFFICE:	RECOMMENDING APPROVAL:	APPROVED:	SHEET CONTENTS:	SHEET NO.:
	CONSTRUCTION OF SECURITY GUARD LOCKER ROOM	 MR. WENCIE S. MANIBOG DRAFTSMAN, OFDM-PDU	 AR. CHERRY L. FABIANES HEAD, OFDM-PDU	 AR. ARLEN M. GUIEB DIRECTOR, OFDM	 DR. JAYSON R. FELIX CIVIL SECURITY OFFICER	 ATTY. WILMARK J. RAMOS, DBA VP FOR ADMINISTRATION	 DR. ARNOLD E. VELASCO PRESIDENT	AS SHOWN	A - 12
	PROJECT LOCATION:							PAGE NO.:	12/16
	SAN ISIDRO & LUCINDA CAMPUS, TARLAC STATE UNIVERSITY							DATE: FEBRUARY 2025	

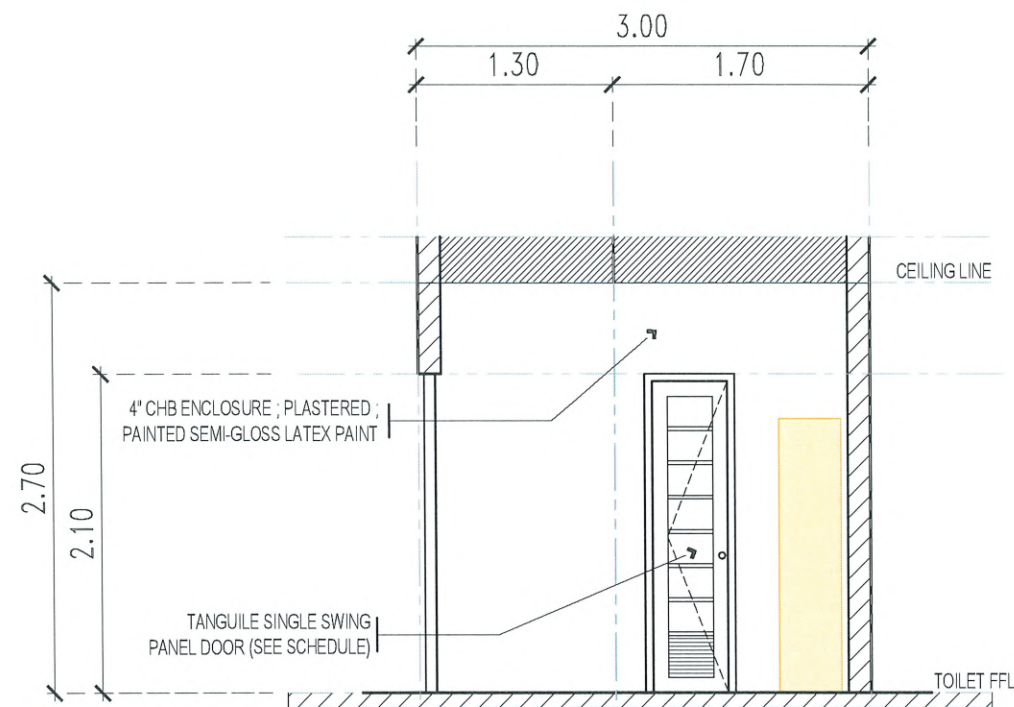


SECTION - K

SCALE 1:70M

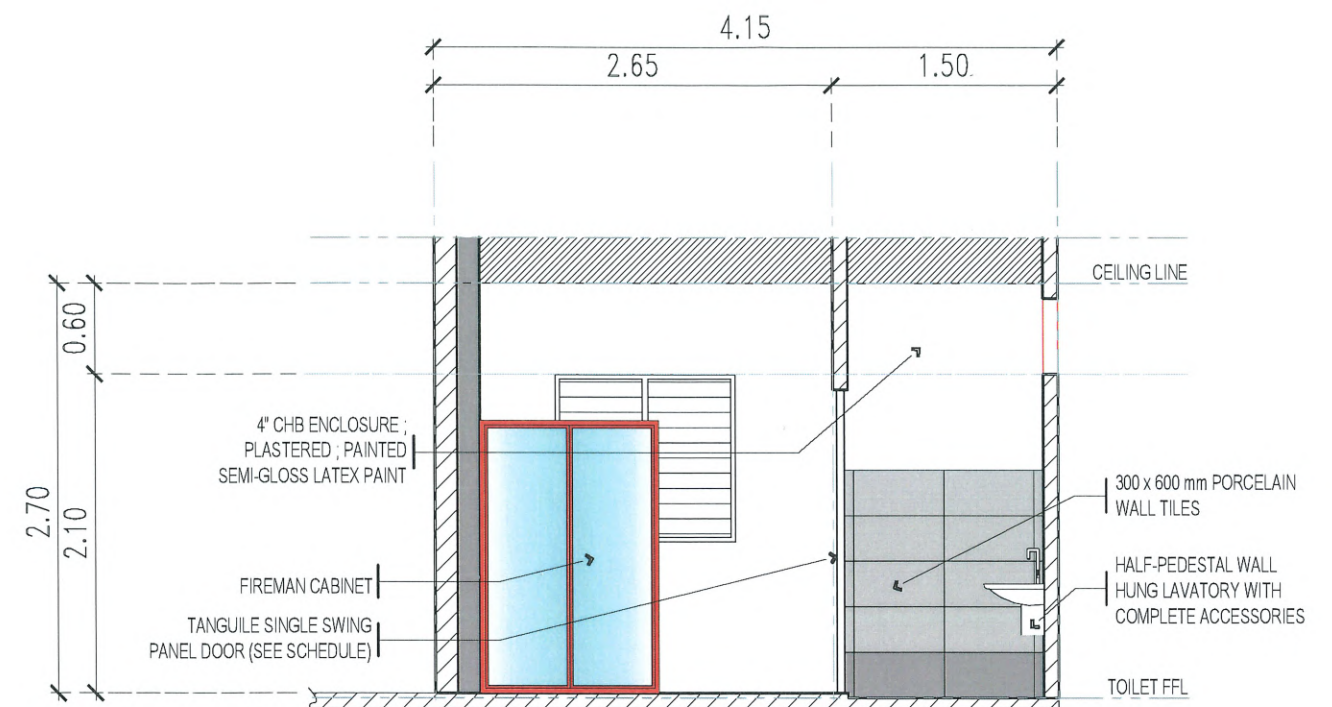


SECTION - H

SCALE 1:70M

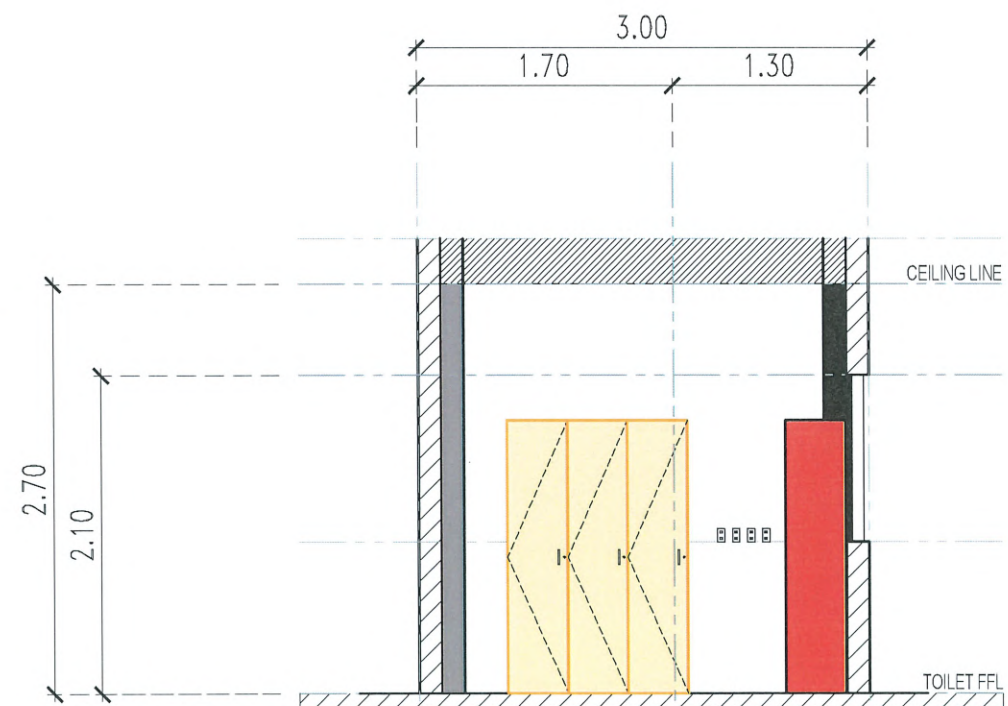

SECTION - L

SCALE 1:70M

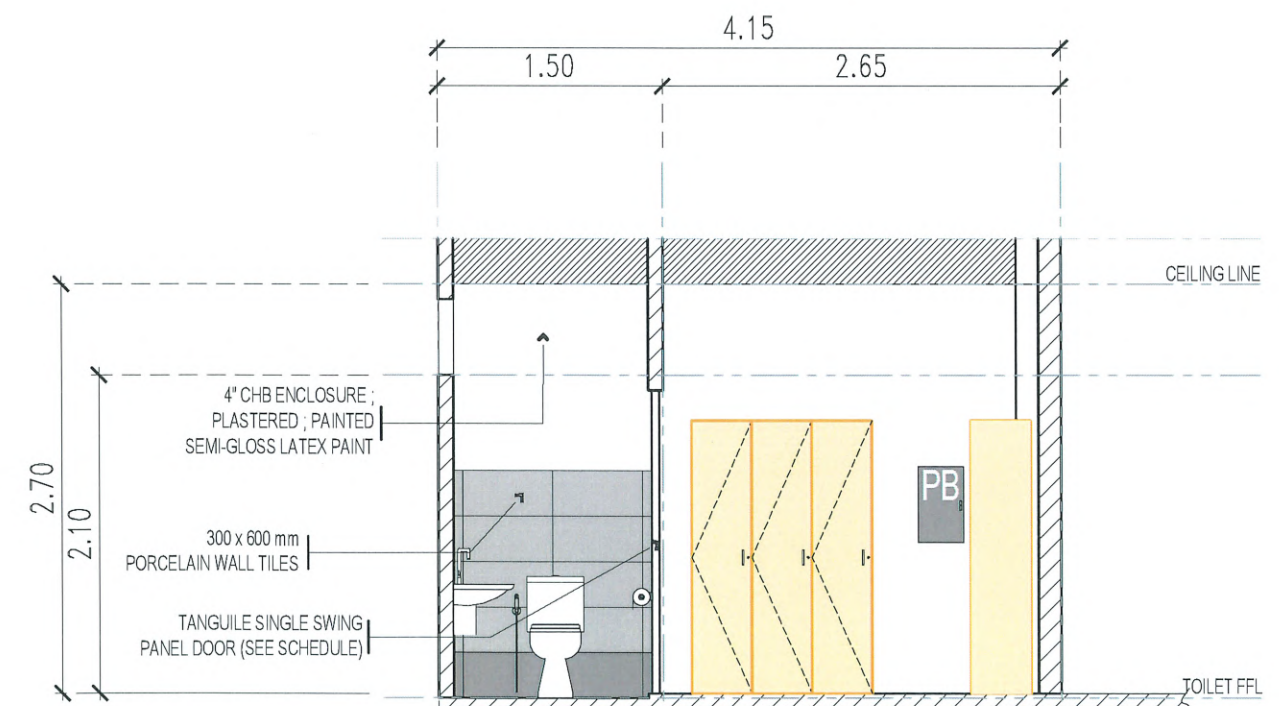

SECTION - J

SCALE 1:70M



TARLAC STATE UNIVERSITY
Facilities Development and
Management Office
Romulo Boulevard, Tarlac City, Philippines 2300

PROJECT TITLE:
CONSTRUCTION OF SECURITY GUARD LOCKER ROOM
PROJECT LOCATION:
SAN ISIDRO & LUCINDA CAMPUS,
TARLAC STATE UNIVERSITY

PREPARED BY:

MR. WENCIE S. MANABOG
DRAFTSMAN, OFDM-PDU

CHECKED BY:

AR. CHERRY L. FABIANES
HEAD, OFDM-PDU

CERTIFIED BY:

AR. ARLEN M. GUIEB
DIRECTOR, OFDM

REQUESTING OFFICE:

DR. JAYSON R. FELIX
CIVIL SECURITY OFFICER

RECOMMENDING APPROVAL:


ATTY. WILMARK J. RAMOS, DBA
VP FOR ADMINISTRATION

APPROVED:

DR. ARNOLD E. VELASCO
PRESIDENT

SHEET CONTENTS:
AS SHOWN
DATE: FEBRUARY 2025


SHEET NO:
A - 13
PAGE NO:
13/16

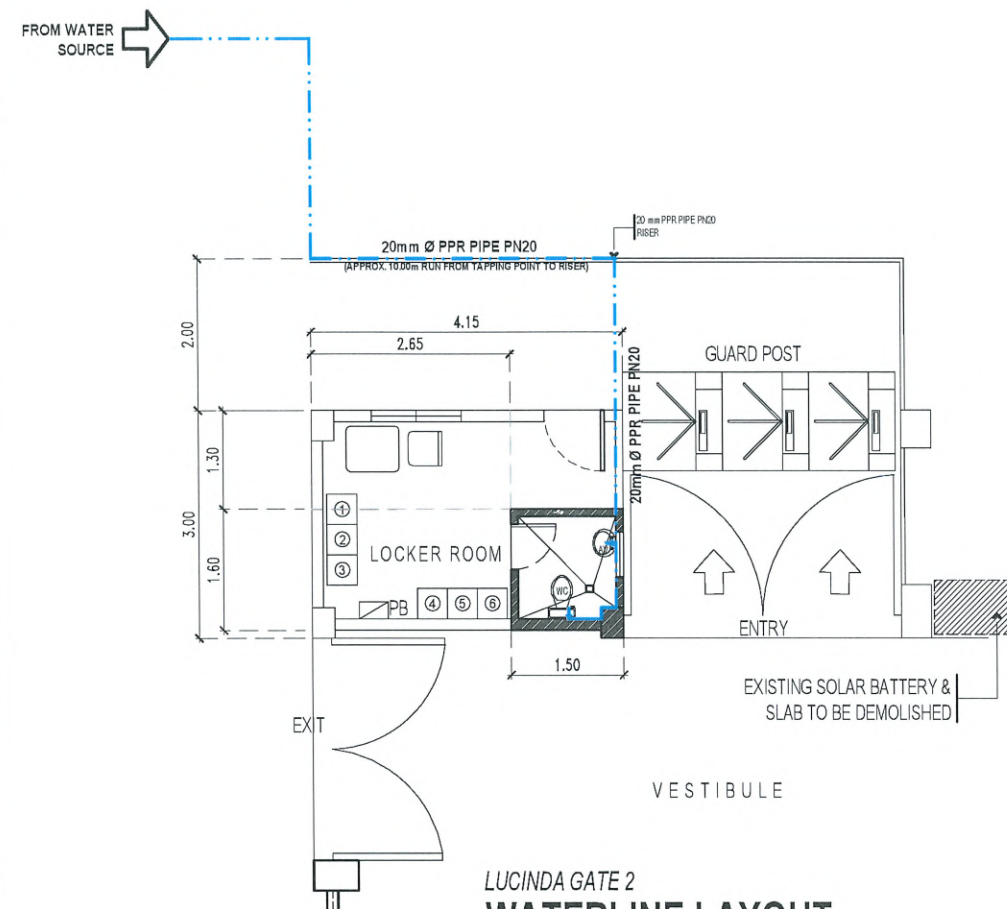

LUCINDA GATE 2
WATERLINE LAYOUT

SCALE 1:100M

NOTE: WORK INCLUDES DEMOLITION, REPAIR, AND RESTORATION OF AFFECTED AREAS FOR PIPE LAYING WORKS

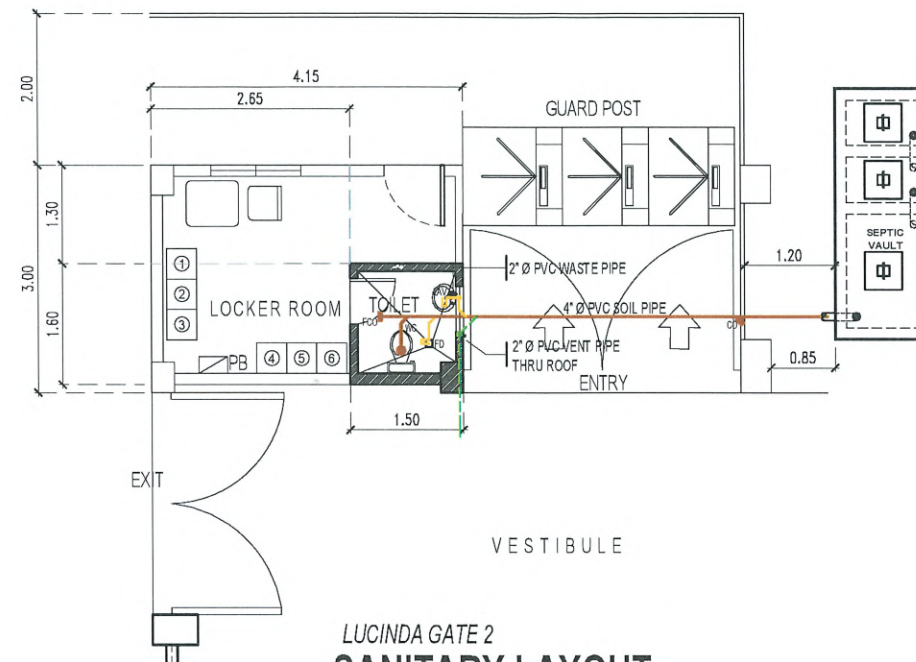


LUCINDA GATE 2
SANITARY LAYOUT


SCALE 1:100M

GENERAL NOTES

- GRADE OF THE HORIZONTAL PIPING:**
RUN ALL HORIZONTAL PIPING IN PERFECT ALIGNMENT AT THE UNIFORM GRADE OF NOT LESS THAN (2%).
- CHANGES IN DIRECTION:**
ALL CHANGES IN DIRECTION SHALL BE MADE BY THE APPROPRIATE USE OF 45° WYE, LONG SWEEP QUARTER BEND, SIXTH, EIGHT, OR SIXTEENTH BENDS, WHEN THE CHANGE OF FLOW IS FROM HORIZONTAL TO VERTICAL A SINGLE 1/8 BEND COMBINATION MAY BE USED ON WASTE, LINES, TEES AND CROSSES MAY BE USED ON VENT PIPES.
- PROHIBITED FITTINGS:**
NO DOUBLE TEE BRANCHES SHALL BE USED ON HORIZONTAL SOIL OR WASTE LINES, DRILLING & TRAPPINGS OF HOUSE DRAINS, WASTE OR VENT PIPES AND USE OF SADDLE HUB AND BENDS ARE PROHIBITED.
- SLEEVES:**
PROVIDE THE PIPE SLEEVES AT WALLS, COLUMNS OR SLAB ON SIZED BIGGER THAN THE ACTUAL SIZE OF THE PIPE PASSING THROUGH WALLS OR UNDER SLABS TO PROTECT PIPES FROM BREAKAGE.
- PIPES CLEANOUTS:**
CLEANOUTS ARE REQUIRED EVERY CHANGE IN HORIZONTAL DIRECTION EXCEEDING TWENTY - TWO AND HALF DEGREES (22 1/2°).
- DEAD ENDS AVOIDED:**
IN THE INSTALLATIONS OF PLUMBING SYSTEM DEAD ENDS SHALL BE AVOIDED.
- ALL PLUMBING WORKS:**
ALL PLUMBING WORKS SHALL BE DONE IN ACCORDANCE WITH THE PROVISIONS OF THE NATIONAL PLUMBING CODE, REQUIREMENTS OF THE PLUMBING INSPECTION OFFICE AND PERTINENT PROVISIONS OF THE NATIONAL BUILDING CODE.

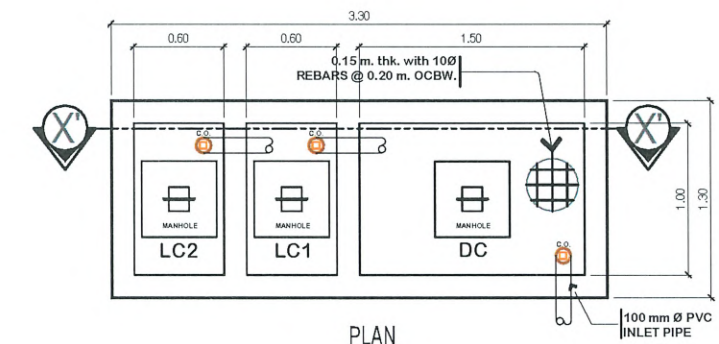


PLAN

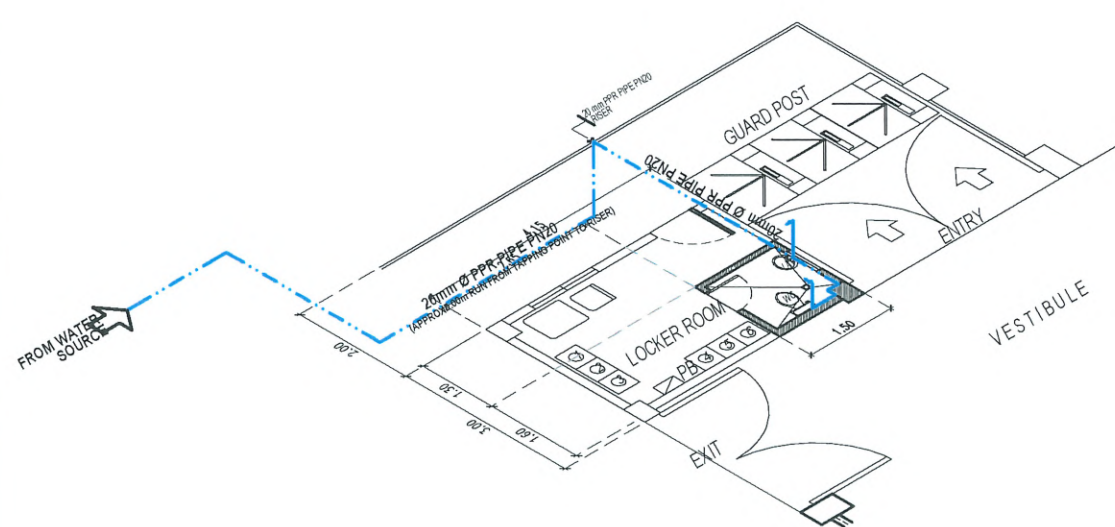


LUCINDA GATE 2
**ISOMETRIC VIEW
WATERLINE LAYOUT**

SCALE 1:100M

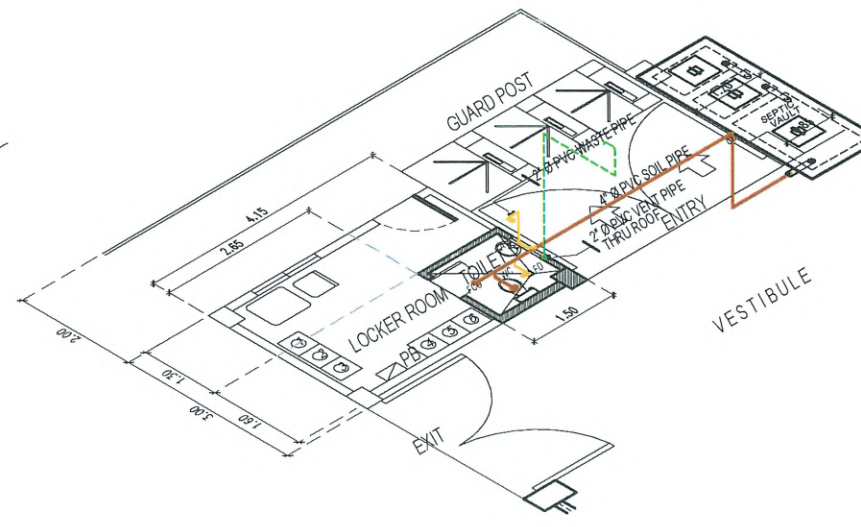

LUCINDA GATE 2
**ISOMETRIC VIEW
SANITARY LAYOUT**

SCALE 1:100M

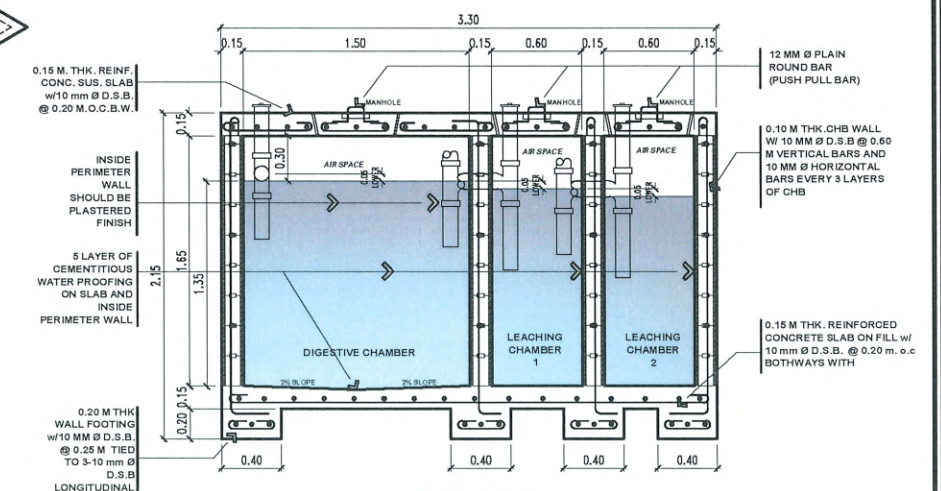

SECTION X'-X'



LUCINDA GATE 2
SEPTIC TANK DETAILS

SCALE 1:50M





TARLAC STATE UNIVERSITY
Facilities Development and
Management Office
Romulo Boulevard, Tarlac City, Philippines 2300

PROJECT TITLE:	CONSTRUCTION OF SECURITY GUARD LOCKER ROOM	PREPARED BY:	AR. PAULO A. DOCTOR, RMP ARCHITECT/MASTER PLUMBER, OFDM	CHECKED BY:	AR. CHERRY L. FABIANES HEAD, OFDM-PDU	CERTIFIED BY:	AR. ARLEN M. GUIEB DIRECTOR, OFDM	REQUESTING OFFICE:	DR. JAYSON R. FELIX CIVIL SECURITY OFFICER	RECOMMENDING APPROVAL:	ATTY. WILMARK J. RAMOS, DBA VP FOR ADMINISTRATION	APPROVED:	DR. ARNOLD E. VELASCO PRESIDENT	SHEET CONTENTS:	AS SHOWN	SHEET NO.:	P - 01
PROJECT LOCATION:	SAN ISIDRO & LUCINDA CAMPUS, TARLAC STATE UNIVERSITY															PAGE NO.:	14/16
																DATE: FEBRUARY 2025	

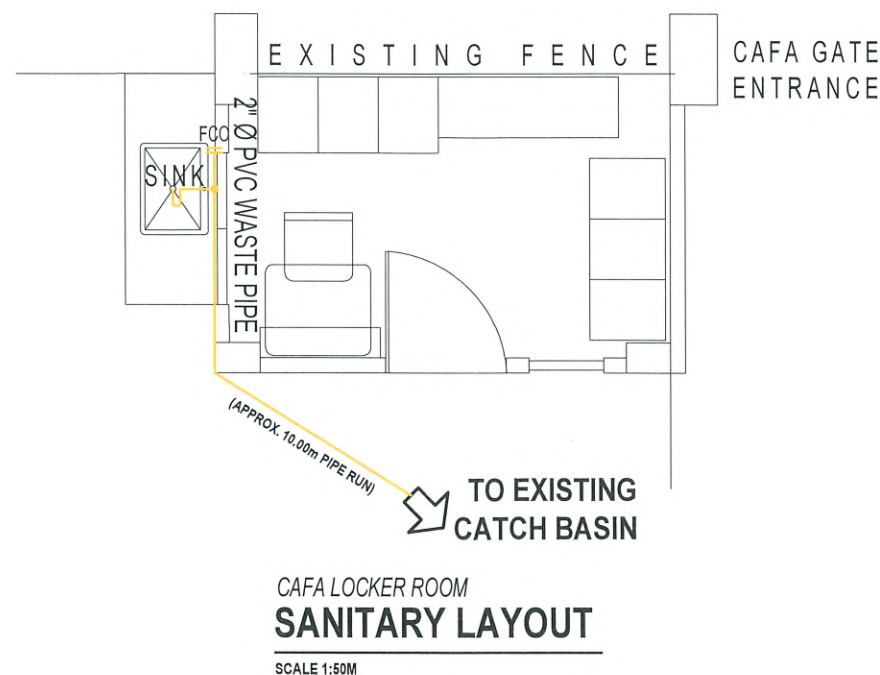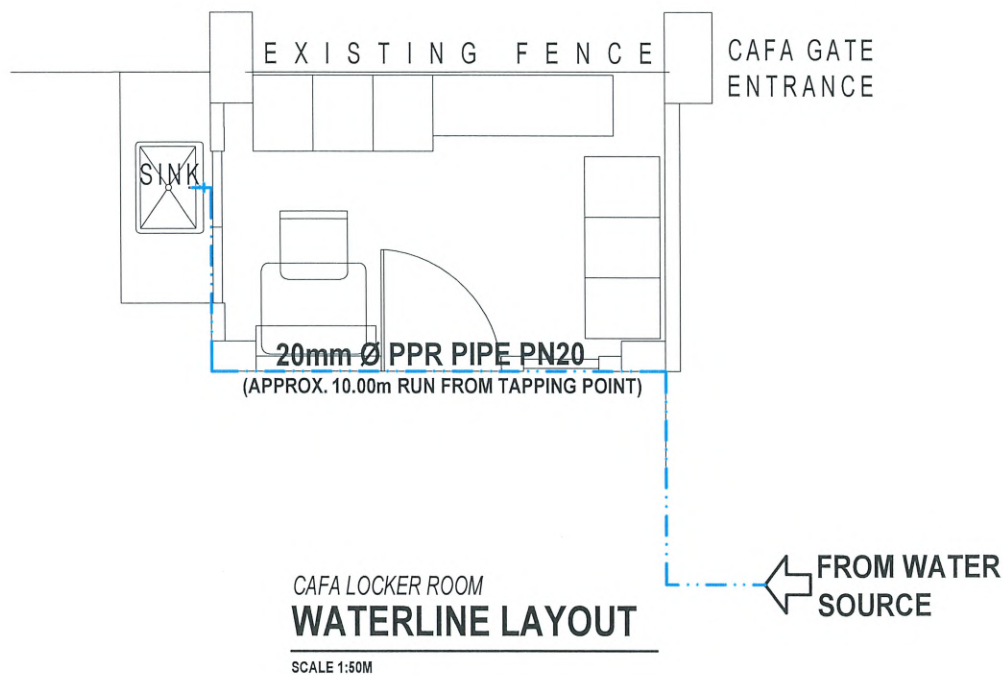

GENERAL NOTES

1. GRADE OF THE HORIZONTAL PIPING:
RUN ALL HORIZONTAL PIPING IN PERFECT ALIGNMENT AT THE UNIFORM GRADE OF NOT LESS THAN (2%).
2. CHANGES IN DIRECTION:
ALL CHANGES IN DIRECTION SHALL BE MADE BY THE APPROPRIATE USE OF 45° WYE, LONG SWEEP QUATER BEND, SIXTH, EIGHT, OR SIXTEENTH BENDS, WHEN THE CHANGE OF FLOW IS FROM HORIZONTAL TO VERTICAL. A SINGLE 1/8 BEND COMBINATION MAY BE USED ON WASTE, LINES, TEES AND CROSSES MAY BE USED ON VENT PIPES.
3. PROHIBITED FITTINGS:
NO DOUBLE TEE BRANCHES SHALL BE USED ON HORIZONTAL SOIL OR WASTE LINES, DRILLING & TRAPPINGS OF HOUSE DRAINS, WASTE OR VENT PIPES AND USE OF SADDLE HUB AND BENDS ARE PROHIBITED.
4. SLEEVES:
PROVIDE THE PIPE SLEEVES AT WALLS, COLUMNS OR SLAB ON SIZED BIGGER THAN THE ACTUAL SIZE OF THE PIPE PASSING THROUGH WALLS OR UNDER SLABS TO PROTECT PIPES FROM BREAKAGE.
5. PIPES CLEANOUTS:
CLEANOUTS ARE REQUIRED EVERY CHANGE IN HORIZONTAL DIRECTION EXCEEDING TWENTY - TWO AND HALF DEGREES (22 1/2°).
6. DEAD ENDS AVOIDED:
IN THE INTALLATIONS OF PLUMING SYSTEM DEAD ENDS SHALL BE AVOIDED.
7. ALL PLUMBING WORKS:
ALL PLUMBING WORKS SHALL BE DONE IN ACCORDANCE WITH THE PROVISIONS OF THE NATIONAL PLUMBING CODE, REQUIREMENTS OF THE PLUMBING INSPECTION OFFICE AND PERTINENT PROVISIONS OF THE NATIONAL BUILDING CODE.

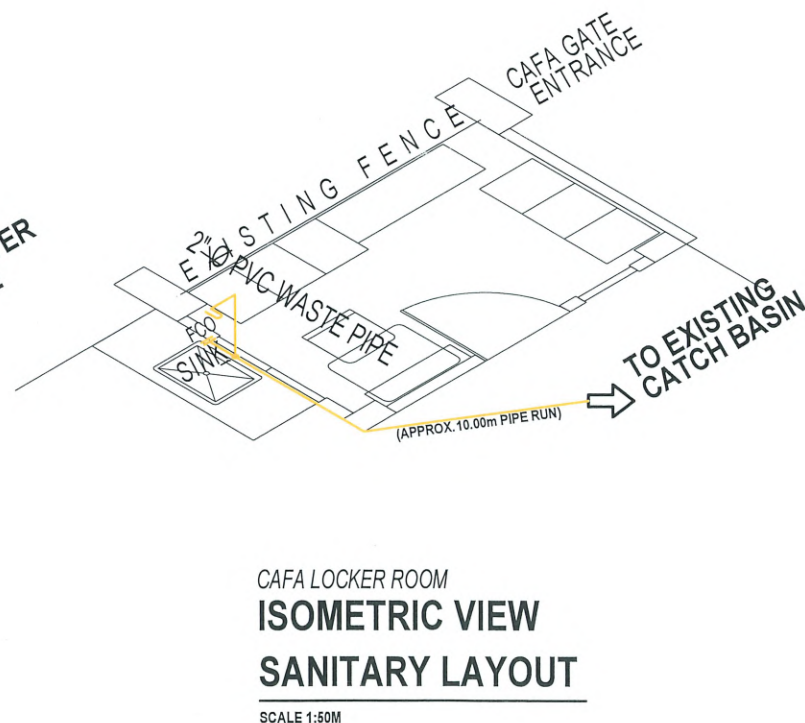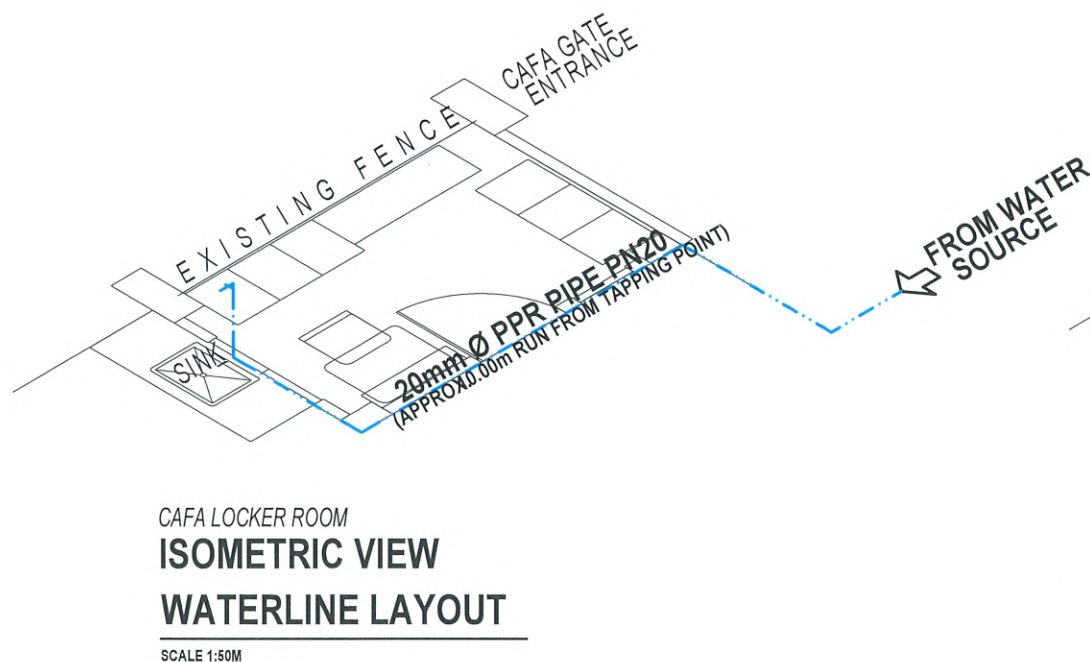

NOTE: WORK INCLUDES DEMOLITION, REPAIR, AND RESTORATION OF AFFECTED AREAS FOR PIPE LAYING WORKS



TARLAC STATE UNIVERSITY
Facilities Development and
Management Office
Romulo Boulevard, Tarlac City, Philippines 2300

PROJECT TITLE:
CONSTRUCTION OF SECURITY GUARD LOCKER ROOM
PROJECT LOCATION:
SAN ISIDRO & LUCINDA CAMPUS,
TARLAC STATE UNIVERSITY

PREPARED BY:

AR. PAULO A. DOCTOR, RMP
ARCHITECT, MASTER PLUMBER, OFDM

CHECKED BY:

AR. CHERRY L. FABIANES
HEAD, OFDM-PDU

CERTIFIED BY:

AR. ARLEN M. GUIEB
DIRECTOR, OFDM

REQUESTING OFFICE:

DR. JAYSON R. FELIX
CIVIL SECURITY OFFICER

RECOMMENDING APPROVAL:

ATTY. WILMARK J. RAMOS, DBA
VP FOR ADMINISTRATION

APPROVED:

DR. ARNOLD E. VELASCO
PRESIDENT

SHEET CONTENTS:
AS SHOWN
DATE: FEBRUARY 2025


SHEET NO.:
P - 02
PAGE NO.:
15/16

GENERAL NOTES & SPECIFICATIONS


1. ALL ELECTRICAL INSTALLATION HEREIN SHALL BE DONE IN ACCORDANCE WITH PROVISIONS OF THE LATEST EDITION OF PHILIPPINE ELECTRICAL CODE WITH THE RULES AND REGULATIONS OF THE NATIONAL AND LOCAL AUTHORITIES CONCERNED IN THE ENFORCEMENT OF ELECTRICAL LAWS AND ORDINANCES AND WITH THE REQUIREMENTS OF THE POWER COMPANY CONCERNED.
2. ALL ELECTRICAL WORKS HEREIN SHALL BE EXECUTED BY EXPERIENCED MEN UNDER THE SUPERVISION OF A DULY LICENSED REGISTERED ELECTRICAL ENGINEER OR PROFESSIONAL ELECTRICAL ENGINEER.
3. MATERIALS THAT PROVIDES SUPPORT, ADDED SAFETY, AND ACCESS, SUCH AS PULL BOXES, JUNCTION BOXES, BENDS AND OTHER FITTINGS SHALL BE PROVIDED EVEN IF NOT EXPLICITLY STATED IN THE PLAN.
4. THE ELECTRICAL SERVICE ENTRANCE POWER FOR THE BUILDING SHALL BE 230V, SINGLE PHASE, 2-WIRE + GROUND, 60 HZ.
5. WIRES SHALL BE COLOR CODED AS FOLLOWS:
6. LINE 1 --- RED LINE 2 --- BLACK GROUND --- GREEN
7. WIRING METHOD SHALL BE AS FOLLOWS:
 - a. FOR EMBEDDED PIPE -POLYVINYL CHLORIDE CONDUIT SCHEDULE 40 (PVC SCH 40)
 - b.FOR RUN EXPOSED PIPE -ELECTRICAL METALLIC TUBING (EMT) / INTERMEDIATE METAL CONDUIT (IMC)
 - c.FOR DRYWALL -MICA TUBE, PVC FLEXIBLE HOSE OR PVC SCH 40
7. ALL MATERIALS TO BE USED SHALL BE BRAND NEW AND APPROVED TYPE FOR THE PARTICULAR LOCATION AND PURPOSE OF USAGE.
8. ALL WIRES SHALL BE COPPER AND THERMOPLASTIC INSULATED TYPE "THHN" UNLESS OTHERWISE INDICATED IN THE PLAN. FOR LIGHTING AND POWER OUTLET SYSTEM USE 3.5mm.
9. ANY DISCREPANCY IN LOCATION AND RATING OF ELECTRICAL EQUIPMENT SHALL BE VERIFIED WITH THE OWNER AND CHANGES SHALL BE MADE ACCORDINGLY.

LEGENDS


18W	18W LED SQUARE PANEL LIGHT SURFACE MOUNTED (DAYLIGHT)
12W	12W LED SQUARE PANEL LIGHT SURFACE MOUNTED (DAYLIGHT)
S _a	ONE GANG WIDE SERIES SWITCH
S _f	FAN SWITCH
ORBIT FAN	ORBIT FAN
DUPLX UNIVRSAL OUTLET WITH GROUND	DUPLX UNIVRSAL OUTLET WITH GROUND
ETHERNET CABLE	ETHERNET CABLE

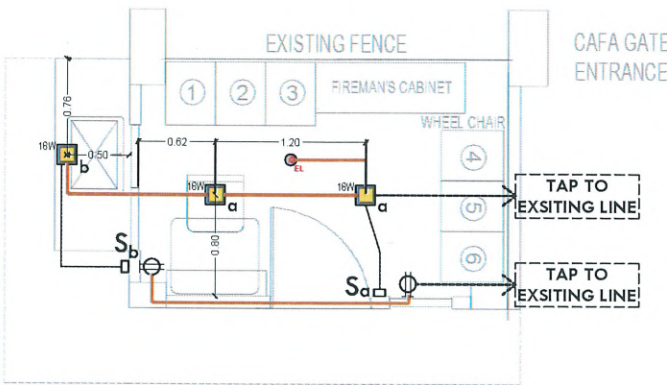


PROPOSED LIGHTING & POWER LAYOUT
CAFA GUARDHOUSE LOCKER
SCALE: 1:60MTS

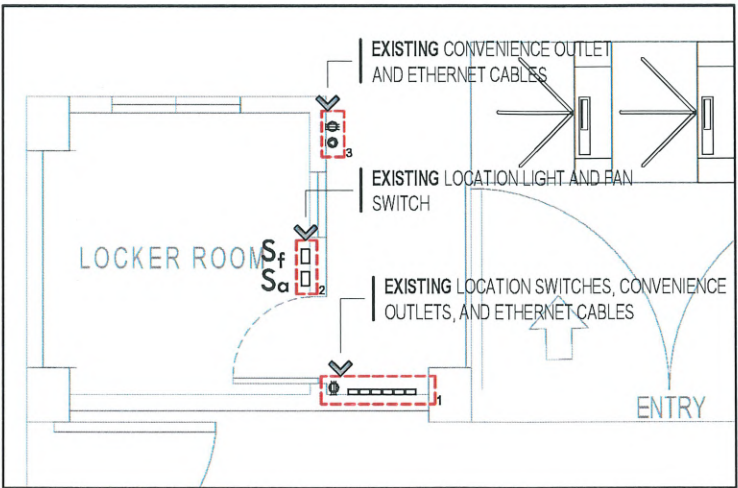

EXISTING ELECTRICAL LAYOUT
LUCINDA GATE 2
SCALE: 1:60MTS

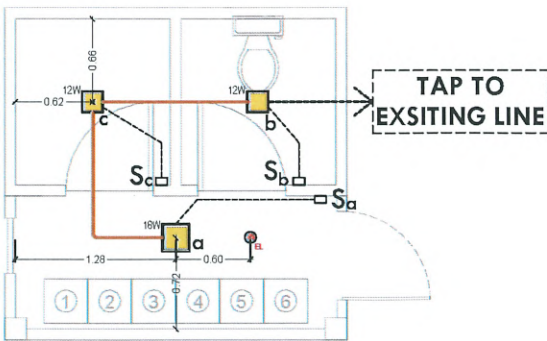


PROPOSED LIGHTING LAYOUT
CCS POWERHOUSE LOCKER
SCALE: 1:60MTS

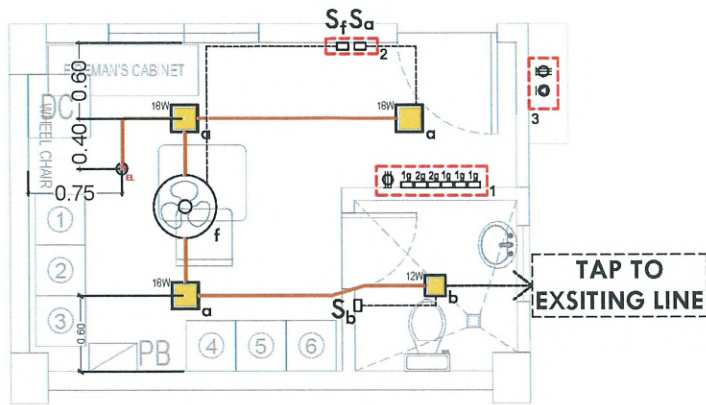

NOTE:
- RELOCATE EXISTING SWITCHES, OUTLETS, AND ETHERNET CABLES AS INDICATED IN THE PLAN.
- RETAIN ALL CONVENIENCE OUTLETS INSIDE THE EXISTING LOCKER ROOM.
- EXPOSED ELECTRICAL WIRINGS AND ETHERNET CABLES SHALL BE ENCLOSED IN A PVC MOULDING.
- EXPOSED JUNCTION BOXES SHALL BE EMBEDDED IN THE WALL.

PROPOSED ELECTRICAL LAYOUT
LUCINDA GATE 2
SCALE: 1:60MTS

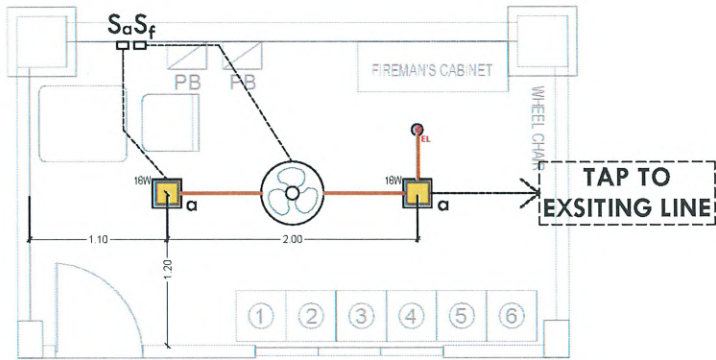

PROPOSED LIGHTING LAYOUT
LUCINDA GATE 1
SCALE: 1:60MTS



TARLAC STATE UNIVERSITY
Facilities Development and
Management Office
Ranula Boulevard, Tarlac City, Philippines 2300

PROJECT TITLE:
CONSTRUCTION OF SECURITY GUARD LOCKER ROOM
PROJECT LOCATION:
SAN ISIDRO & LUCINDA CAMPUS,
TARLAC STATE UNIVERSITY

PREPARED BY:
ENGR. MARK JOMELE O. NATIVIDAD
ELECTRICAL ENGINEER, OFDM-POU

CHECKED BY:
AR. CHERRY L. FABIANES
HEAD, OFDM-POU

CERTIFIED BY:
AR. ARLEN M. GUIEB
DIRECTOR, OFDM

REQUESTING OFFICE:
DR. JAYSON R. FELIX
CIVIL SECURITY OFFICER

RECOMMENDING APPROVAL:
ATTY. WILMARK J. RAMOS, DBA
VP FOR ADMINISTRATION

APPROVED:
DR. ARNOLD E. VELASCO
PRESIDENT

SHEET CONTENTS:
AS SHOWN
DATE: FEBRUARY 2025

SHEET NO:
E - 01
PAGE NO:
16/16